


NOTES:

1. SOME EXISTING AND PROPOSED INFORMATION NOT SHOWN FOR CLARITY.
2. PROPOSED FIBERGLASS LOUVERS SHALL MATCH EXISTING IN COLOR AND TEXTURE. FINAL DESIGN BY FIBERGLASS MANUFACTURER AND SHALL BE APPROVED BY LANDLORD & VERIZON CM.
3. CONDUIT INSTALLATION TO MINIMIZE IMPACT AS MUCH AS POSSIBLE. ALL DISTURBED ITEMS TO BE REPAIRED TO THEIR ORIGINAL CONDITION AND APPROVED BY VERIZON CM AND LL. COORDINATE POWER UPGRADE WITH BELMONT LIGHT AND POWER.
4. PROPOSED EQUIPMENT TO BE INSTALLED PER STRUCTURAL ANALYSIS BY DEWBERRY ENGINEERS INC., DATED 10-12-15.
5. ALL PROPOSED WORK WITHIN STEEPLE TO BE COMPLETED AFTER THE STEEPLE REPAIRS, AS RECOMMENDED BY THE REPORT ISSUED BY RENE MUGNIER ASSOCIATES, INC. DATED 08-27-14 ARE COMPLETED.

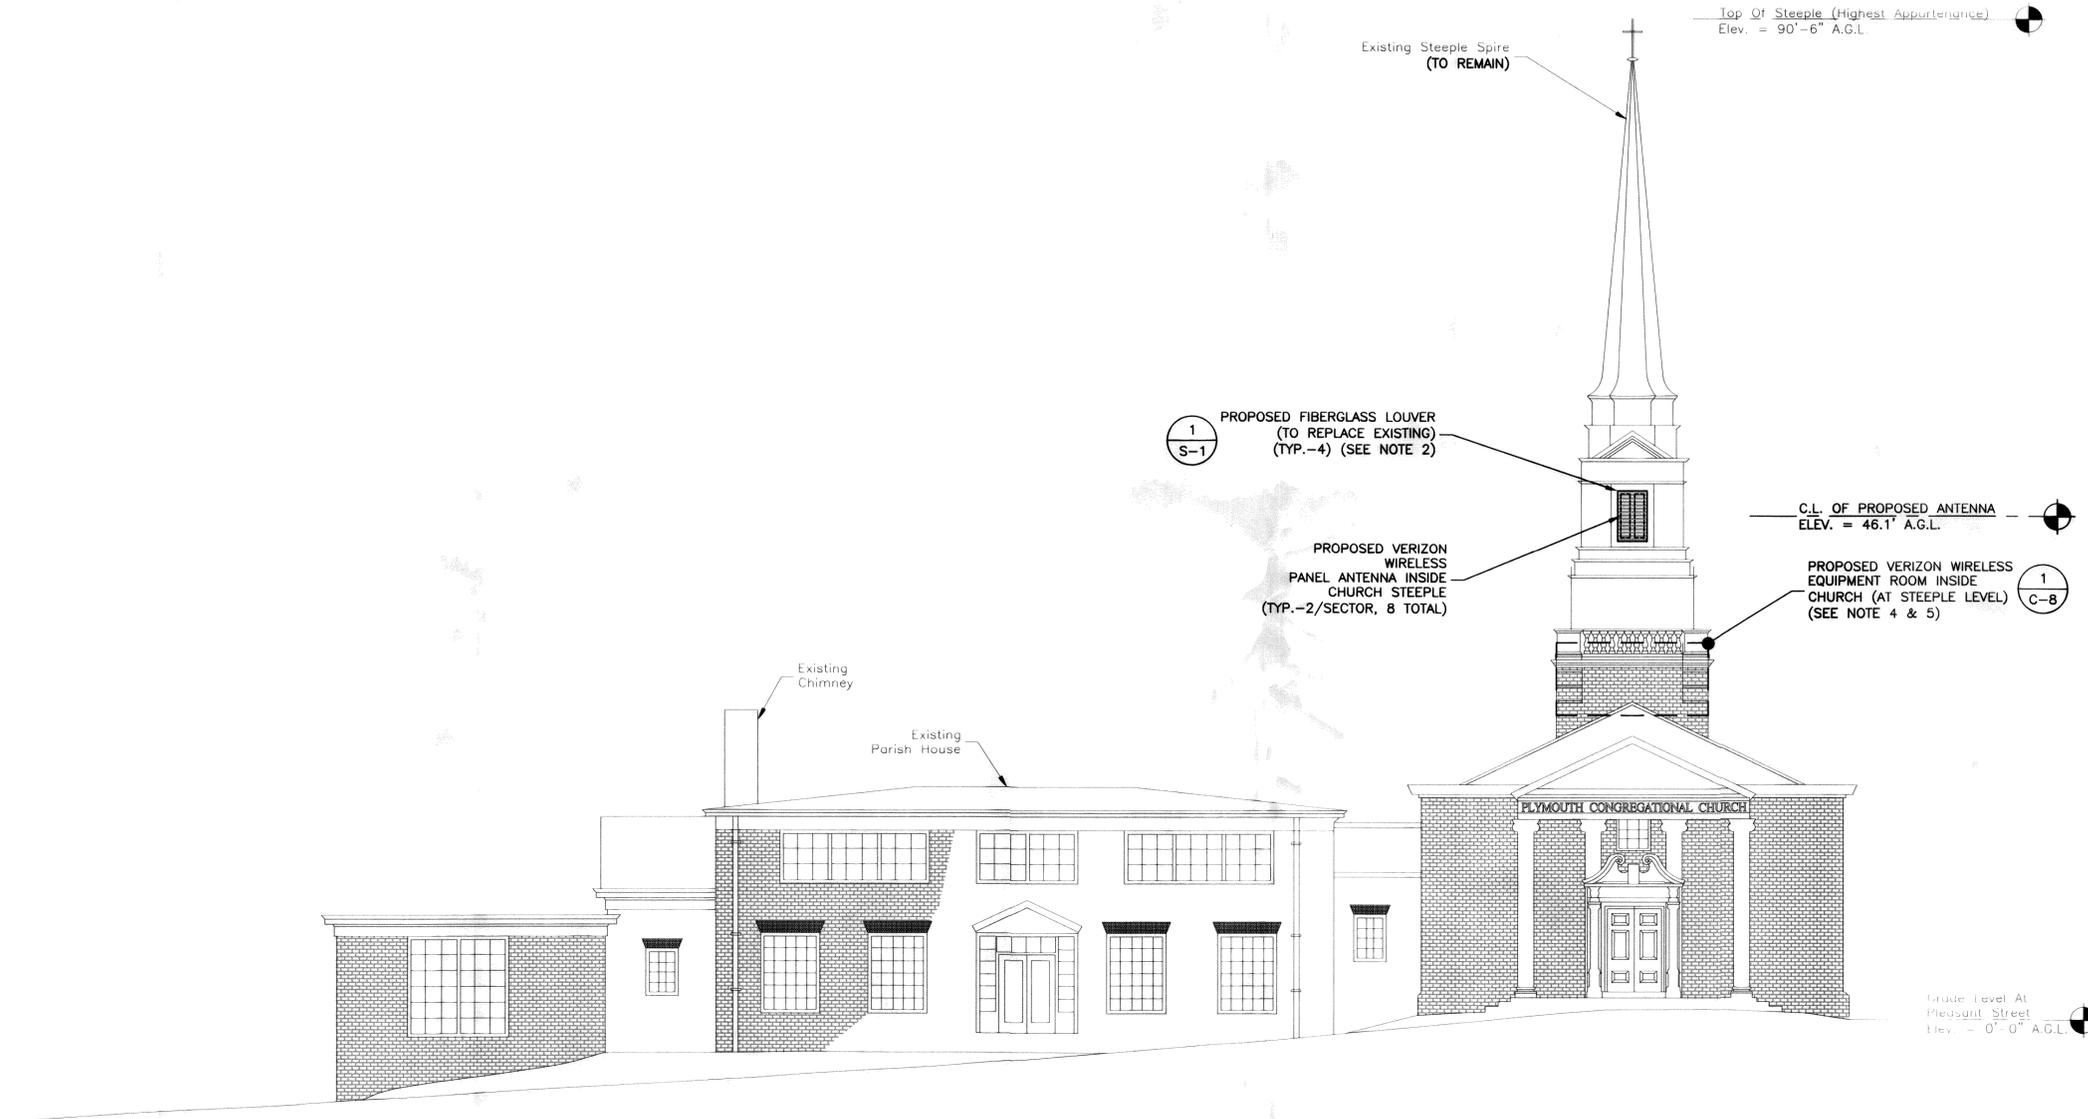

PROPOSED WEST ELEVATION 1
 SCALE: 1/16"=1' FOR 11"x17"
 1/8"=1' FOR 22"x34"
 0' 4' 8' 16'


verizon
 WIRELESS
 VERIZON WIRELESS
 400 FRIBERG PARKWAY
 WESTBOROUGH, MA 01581-3956

BELMONT 3 MA

CONSTRUCTION DRAWINGS

0	11/16/15	FOR CONSTRUCTION
A	09/04/15	FOR REVIEW

Dewberry
 Dewberry Engineers Inc.
 280 SUMMER ST.
 10TH FLOOR
 BOSTON, MA 02210
 PHONE: 617.695.3400
 FAX: 617.695.3310

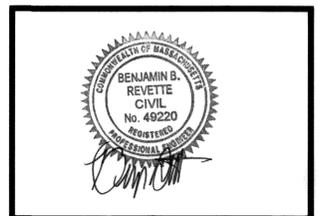

DRAWN BY: MR
 REVIEWED BY: DAS
 CHECKED BY: BBR
 PROJECT NUMBER: 50002925
 JOB NUMBER: 50066098
 SITE ADDRESS:

582 PLEASANT STREET
 BELMONT, MA 02478

SHEET TITLE
 PROPOSED WEST ELEVATION
 SHEET NUMBER