

Belmont Skating & Sports Facility

297 Concord Ave, Belmont, MA 02478

50% Construction Documents

12.11.2023

NOT FOR CONSTRUCTION

DRAWING INDEX

Sheet Number	Sheet Name
<varies>	<varies>
<varies>	<varies>
A-000	Cover
AS-100	Existing Site Plan
<varies>	<varies>
A-102	1st Floor Overall Plan
A-102.1	1st Floor Plan - South
A-102.2	1st Floor Plan - North
A-103.1	1st Floor Dimension Plan - South
A-103.2	1st Floor Dimension Plan - North
A-104.1	1st Floor Reflected Ceiling Plan - South
A-104.2	1st Floor Reflected Ceiling Plan - North
A-105.1	Roof Plan - South
A-105.2	Roof Plan - North
A-106.1	Roof Dimension Plan - South
A-106.2	Roof Dimension Plan - North
A-107.1	1st Floor Furniture Plan - South
A-107.2	1st Floor Furniture Plan - North
A-108	1st Floor Finish Plan
A-201	Building Elevations

Sheet Number	Sheet Name
A-202	Building Elevations
A-203	East Building Elevations
A-204	West Building Elevations
A-300	Building Sections
A-301	Building Sections
A-302	East Building Sections
A-303	West Building Sections
<varies>	<varies>
A-316	South Wall Sections
A-401	Interior Elevations
A-402	Interior Elevations
A-403	Interior Elevations
A-404	Interior Elevations
A-405	Interior Elevations
A-406	Interior Elevations
A-407	Interior Elevations
A-408	Interior Elevations
A-409	Interior Elevations
A-410	Interior Elevations
A-411	Interior Elevations

Sheet Number	Sheet Name
A-500	Enlarged Plans
A-501	Enlarged Plans
A-502	Enlarged Plans
<varies>	Enlarged Plans
A-505	Typical Details
A-600	Partition Types
A-601	Finish Schedule
A-602	Door Types & Schedule
A-603	Window Types & Schedule
A-604	Typical Door & Window Details
A-700	SW 3D View
A-701	NW 3D View
A-702	NE 3D View
A-703	SE 3D View
A-705	Interior 3D Section View 2
A-706	Interior 3D Section View 3
A-704	Interior 3D Section View 1



Location Within City of Boston




Location Within Belmont



In conformation with the Commonwealth of Massachusetts State Building Code, I hereby certify to the best of my knowledge that the plans, computations and specifications meet the applicable provisions of said code, all acceptable engineering practices and all applicable laws and ordinances.



The Galante Architecture Studio, Inc. expressly reserves the common law copyrights in these drawings. These drawings are not to be reproduced in any manner, nor are they to be assigned to a third party without the expressed written permission and consent of The Galante Architecture Studio, Inc.

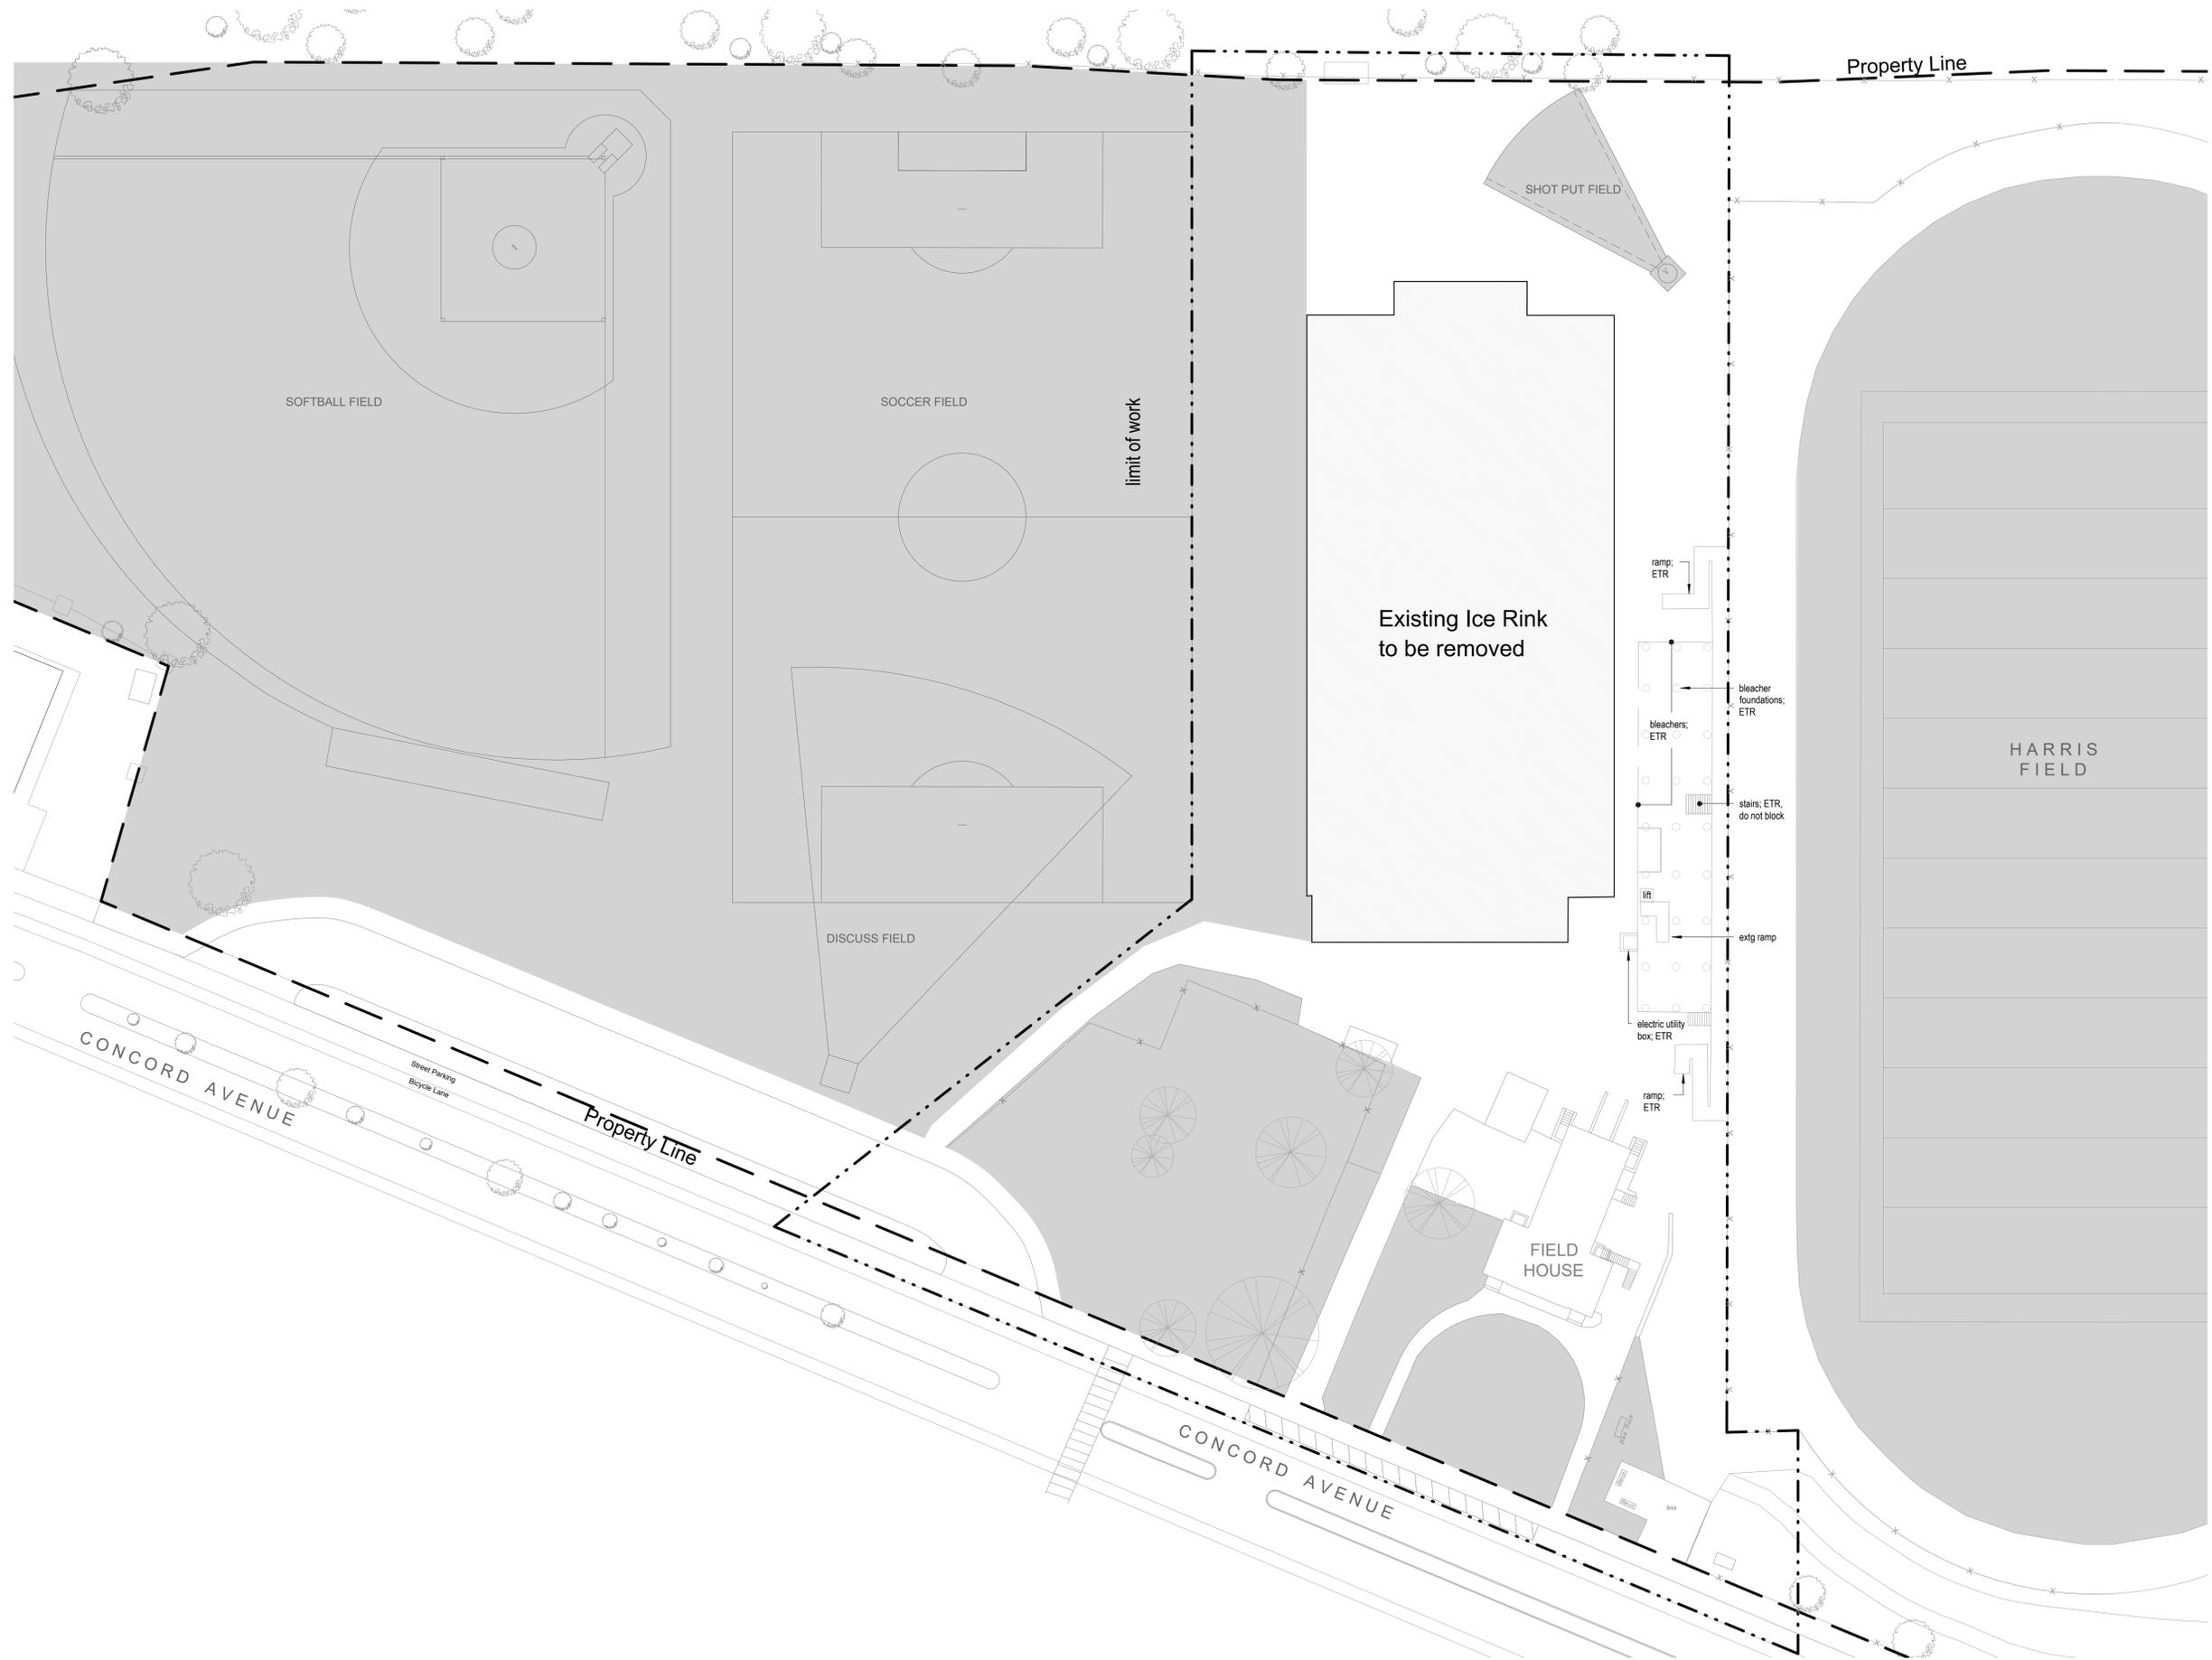


TGAS

THE GALANTE
ARCHITECTURE
STUDIO INC

146 MT AUBURN ST CAMBRIDGE, MA 02138

6 1 7 5 7 6 2 5 0 0

 WWW.GALANTEARCHITECTURE.COM



Project Number
2202

Project Title
Belmont Skating &
Sports Facility

297 Concord Ave,
Belmont, MA 02478

Drawing Title
Existing Site Plan

50% Construction
Documents

Date/Issued For
12.11.2023

**NOT FOR
CONSTRUCTION**

Print 24 x 36

 
Scale
1" = 30'-0"

Drawn By
CT

Drawing Number

AS-100

1 Existing Site Plan
1" = 30'-0"



Project Number
2202

Project Title
Belmont Skating &
Sports Facility

297 Concord Ave,
Belmont, MA 02478

Drawing Title
Architectural Site
Plan

50% Construction
Documents

Date/Issued For
12.11.2023

**NOT FOR
CONSTRUCTION**


Print 24 x 36

Scale
1" = 30'-0"

Drawn By
CJB

Drawing Number


AS-101

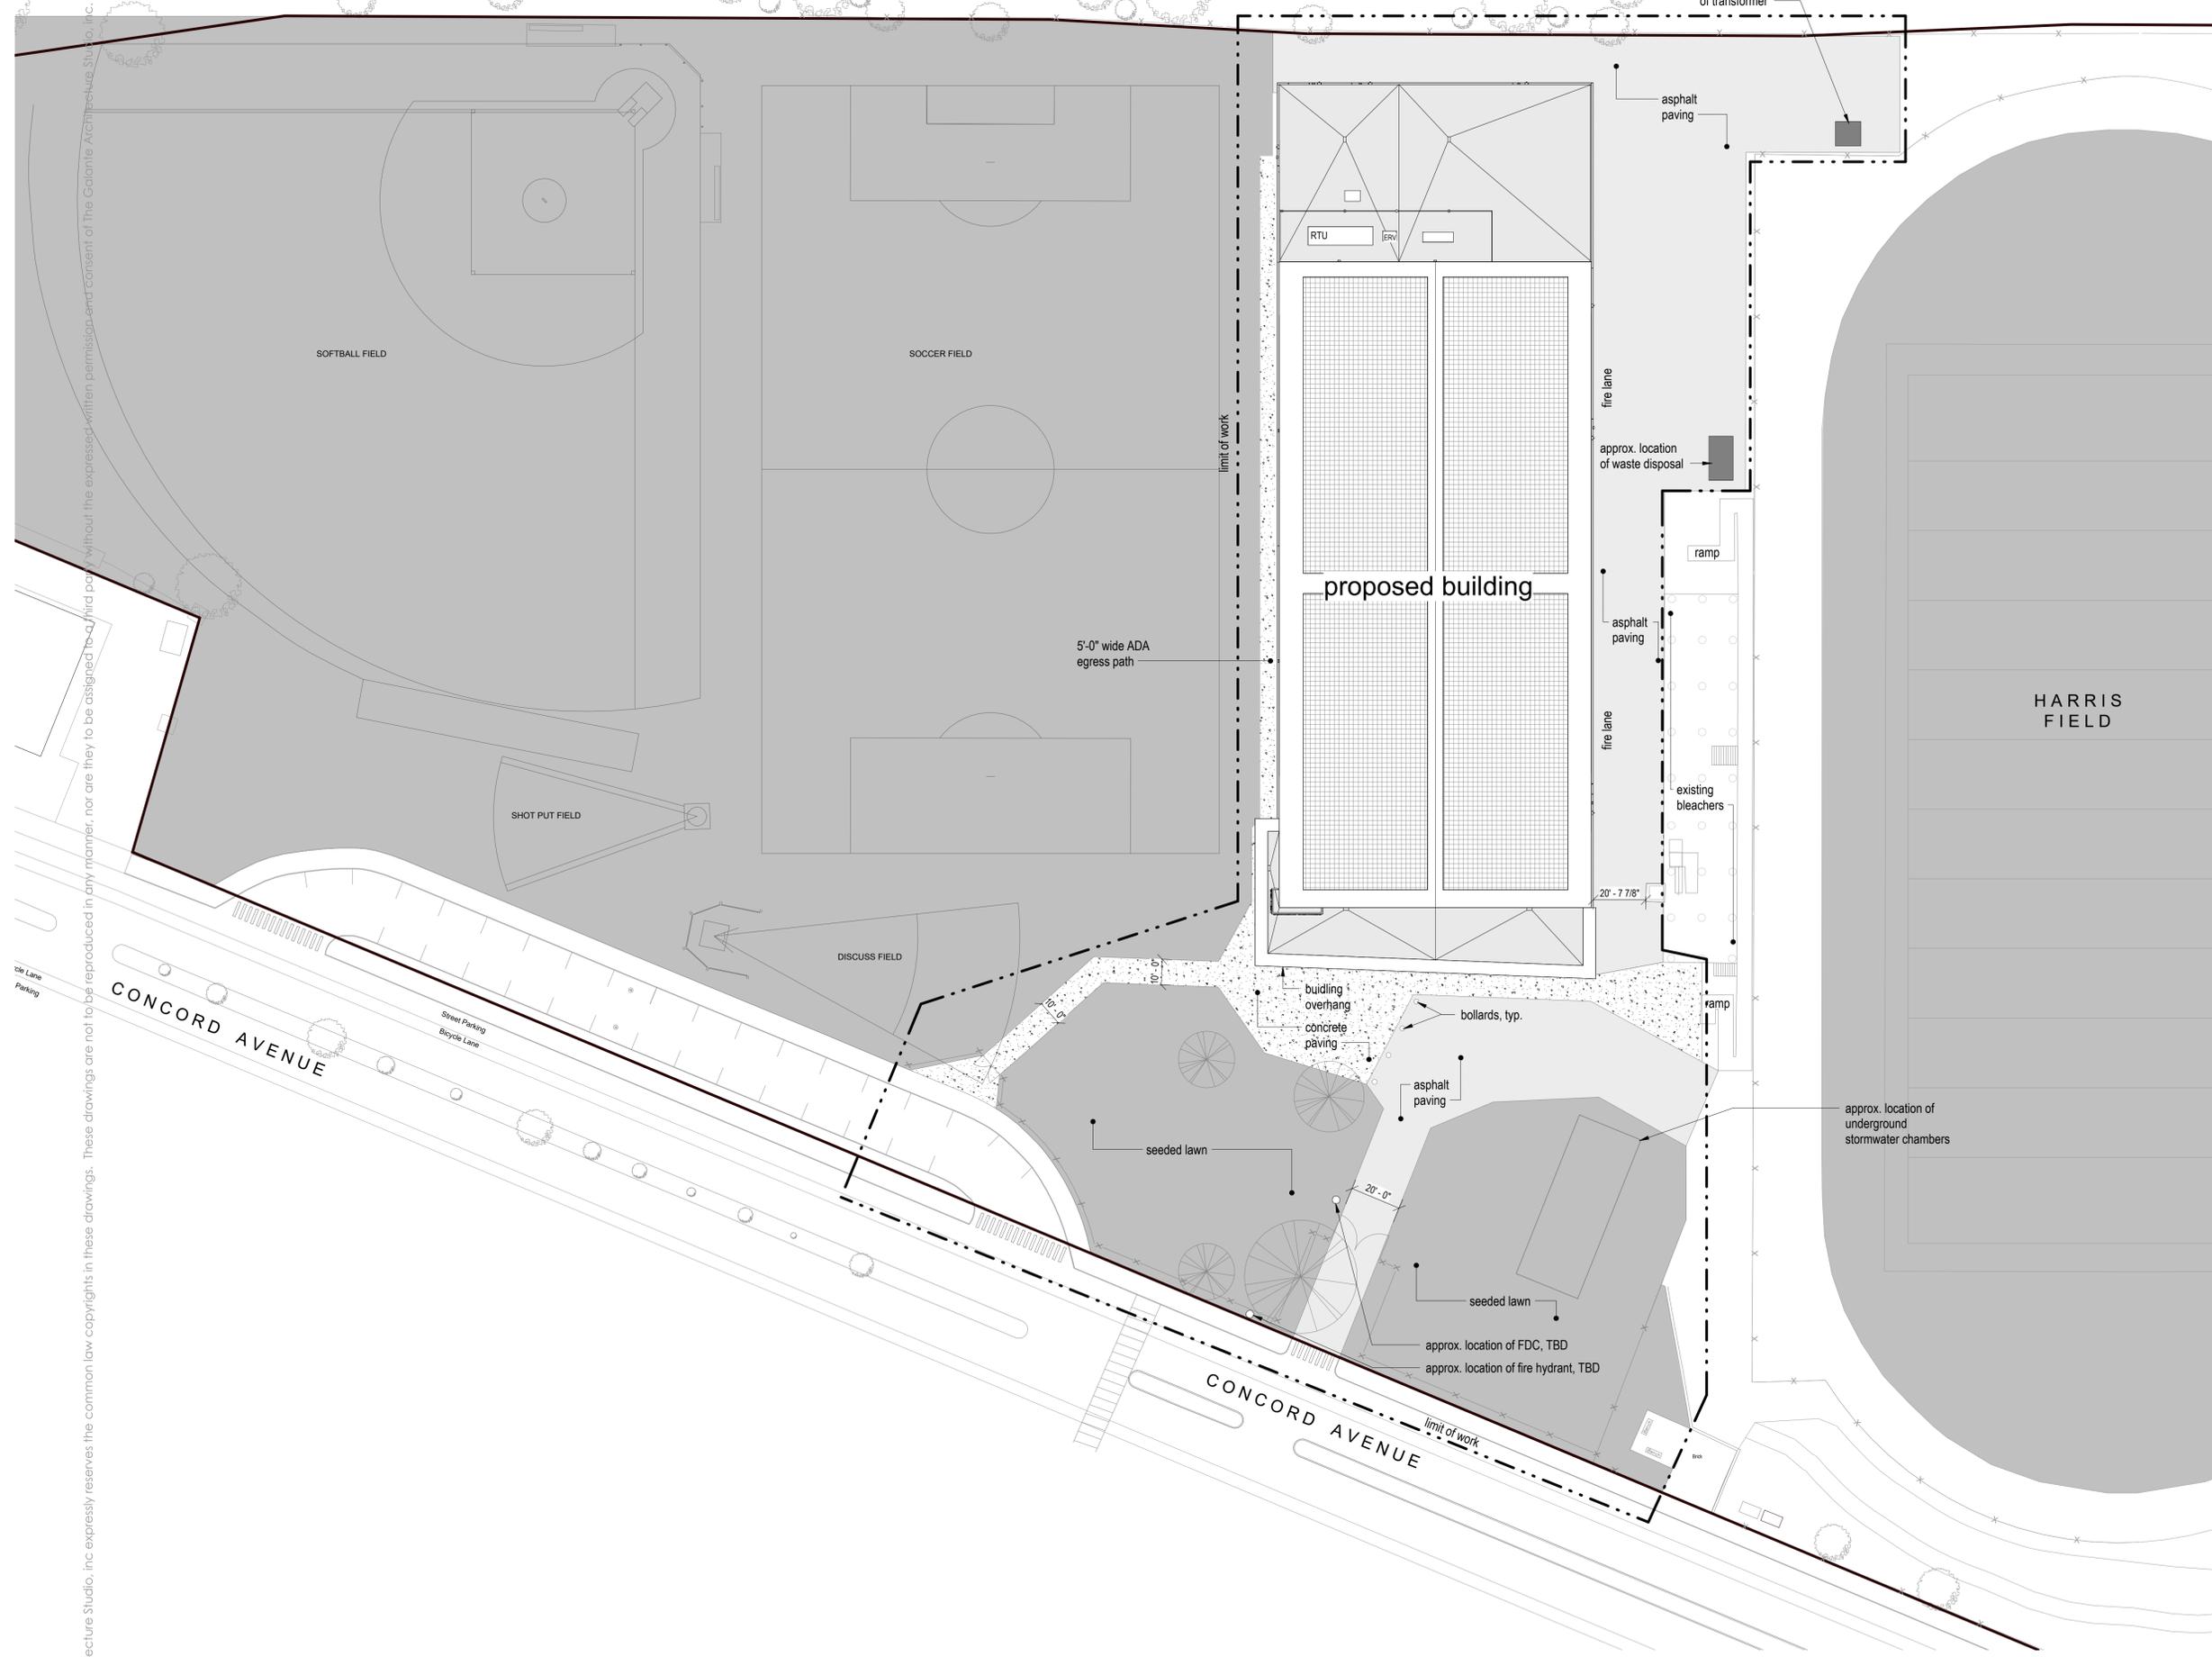


1 Site Plan - Proposed
 1" = 30'-0"

The Galante Architecture Studio, Inc. expressly reserves the common law copyrights in these drawings. These drawings are not to be reproduced in any manner, nor are they to be assigned to a third party without the expressed written permission and consent of The Galante Architecture Studio, Inc.

The Galante Architecture Studio, Inc. expressly reserves the common law copyrights in these drawings. These drawings are not to be reproduced in any manner, nor are they to be assigned to a third party without the expressed written permission and consent of The Galante Architecture Studio, Inc.

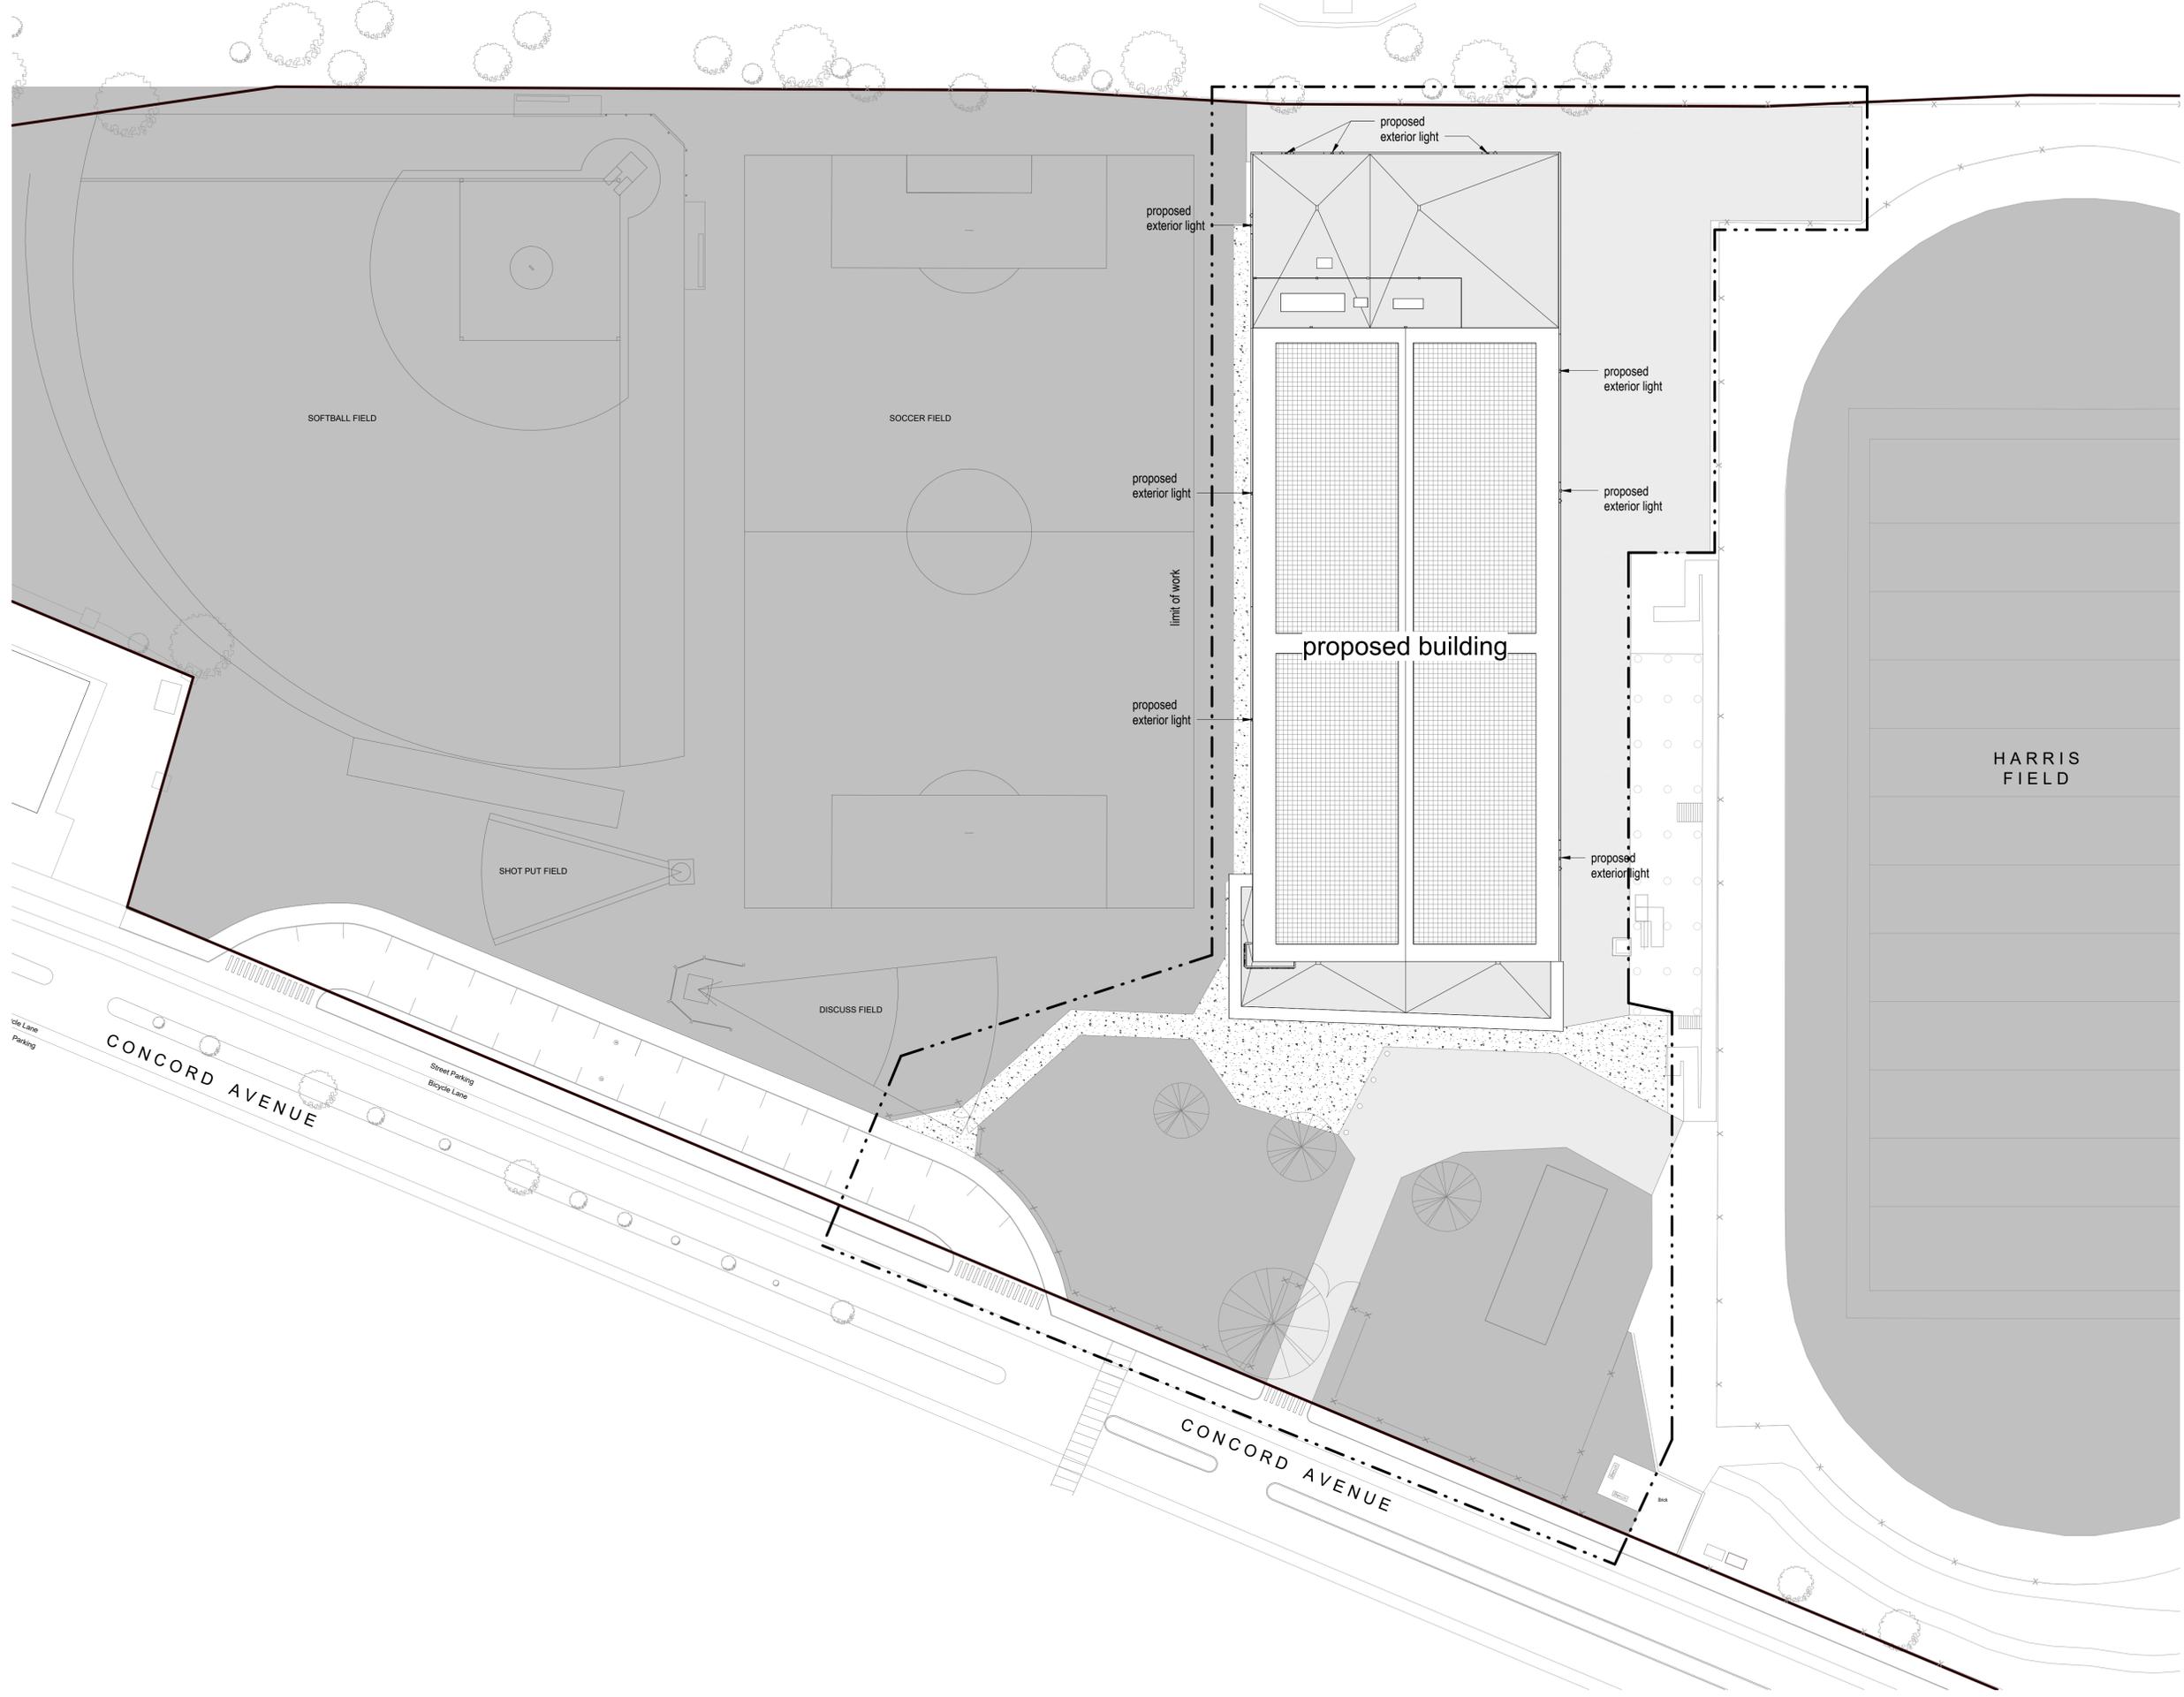

 TGAS
THE GALANTE
ARCHITECTURE
STUDIO INC
146 MT AUBURN ST CAMBRIDGE, MA 02138
6 1 7 5 7 6 2 5 0 0
WWW.GALANTEARCHITECTURE.COM



Project Number
2202
Project Title
Belmont Skating &
Sports Facility

297 Concord Ave,
Belmont, MA 02478

Drawing Title
Proposed Site
Lighting Plan

50% Construction
Documents

Date/Issued For
12.11.2023

 
**NOT FOR
CONSTRUCTION**

Scale
1" = 30'-0"

Drawn By
CT

Drawing Number
AS-103

1 Site Lighting Plan
1" = 30'-0"



Project Number
2202

Project Title
Belmont Skating &
Sports Facility

297 Concord Ave,
Belmont, MA 02478

Drawing Title
1st Floor Overall
Plan

50% Construction
Documents

Date/Issued For
12.11.2023

**NOT FOR
CONSTRUCTION**


Print 24 x 36

Scale
1/16" = 1'-0"


Drawn By
CT

Drawing Number

A-102

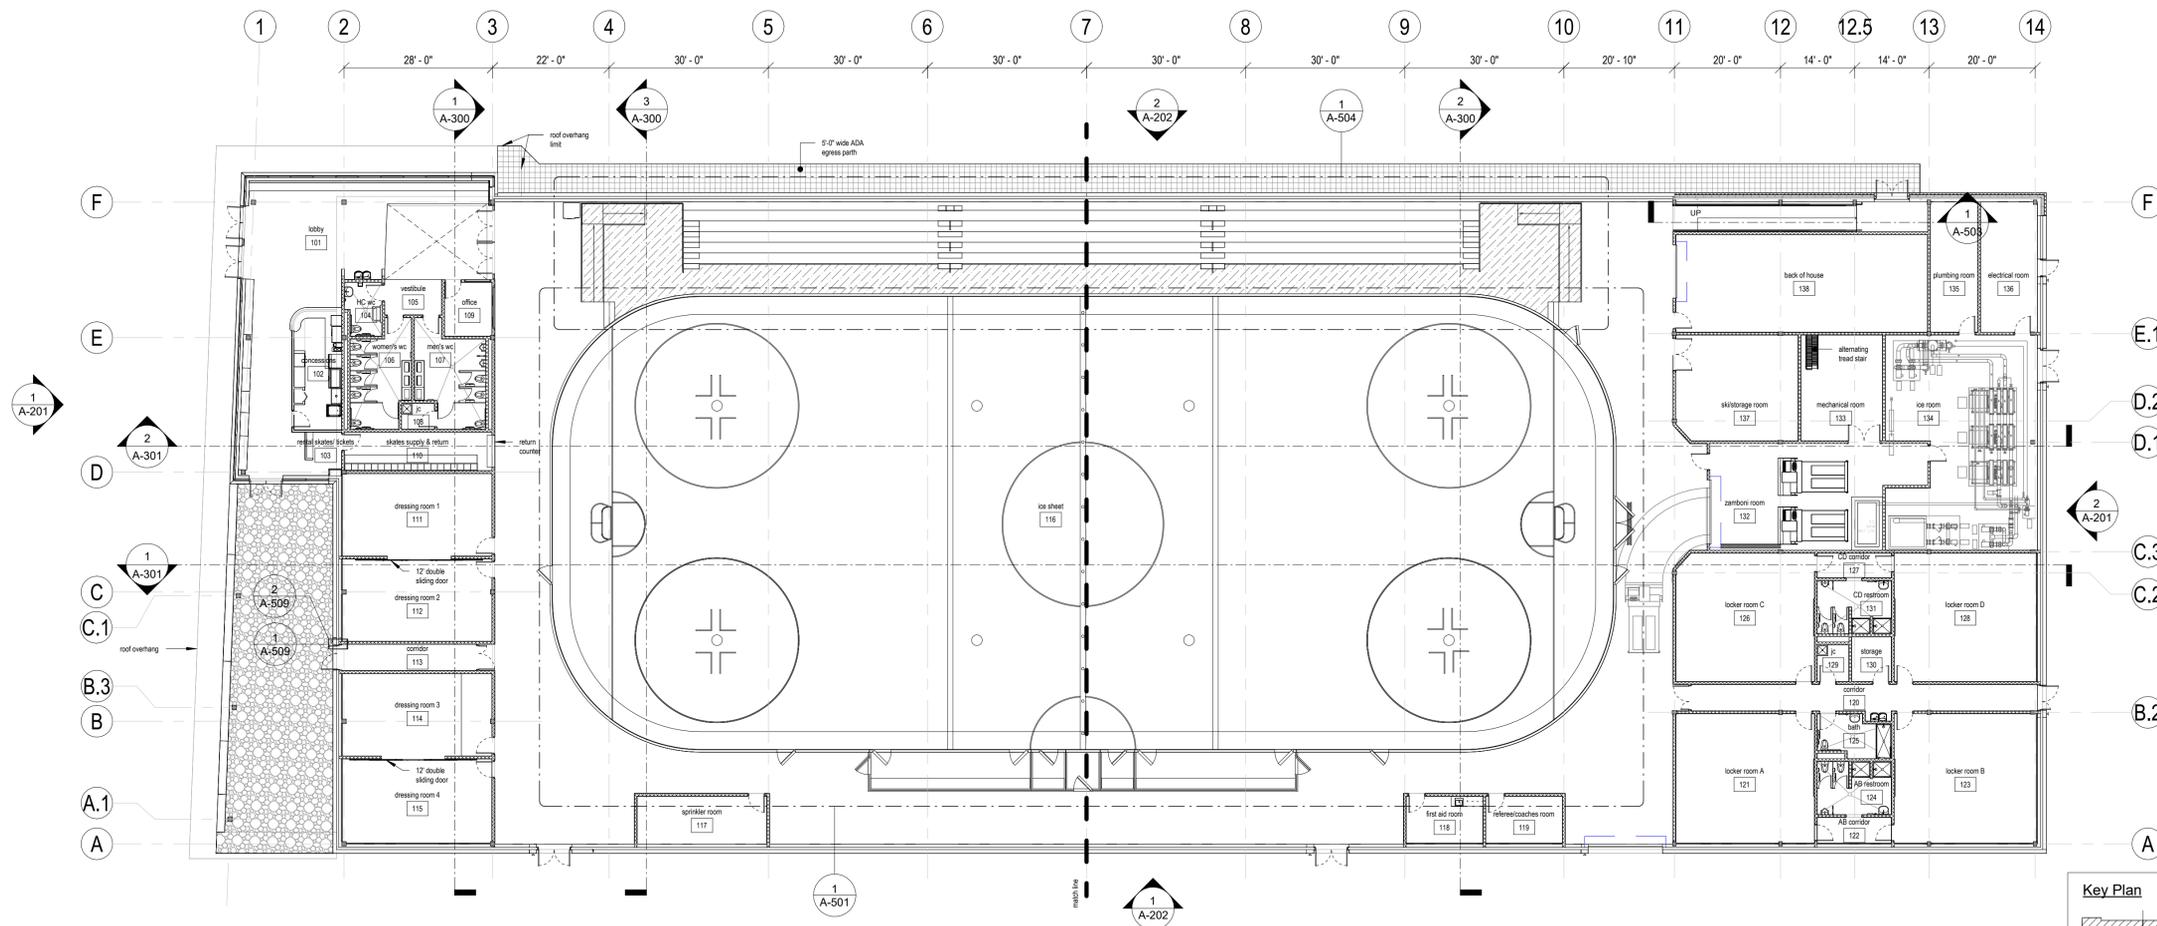

1 1st Floor Overall Plan
1/16" = 1'-0"

 

Project Number
2202

Project Title
Belmont Skating &
Sports Facility

297 Concord Ave,
Belmont, MA 02478

Drawing Title
1st Floor Plan -
South

50% Construction
Documents

Date/Issued For
12.11.2023

**NOT FOR
CONSTRUCTION**



Print 24 x 36

Scale
1/8" = 1'-0"

Drawn By
CT

Drawing Number

A-102.1

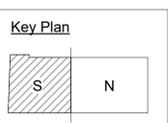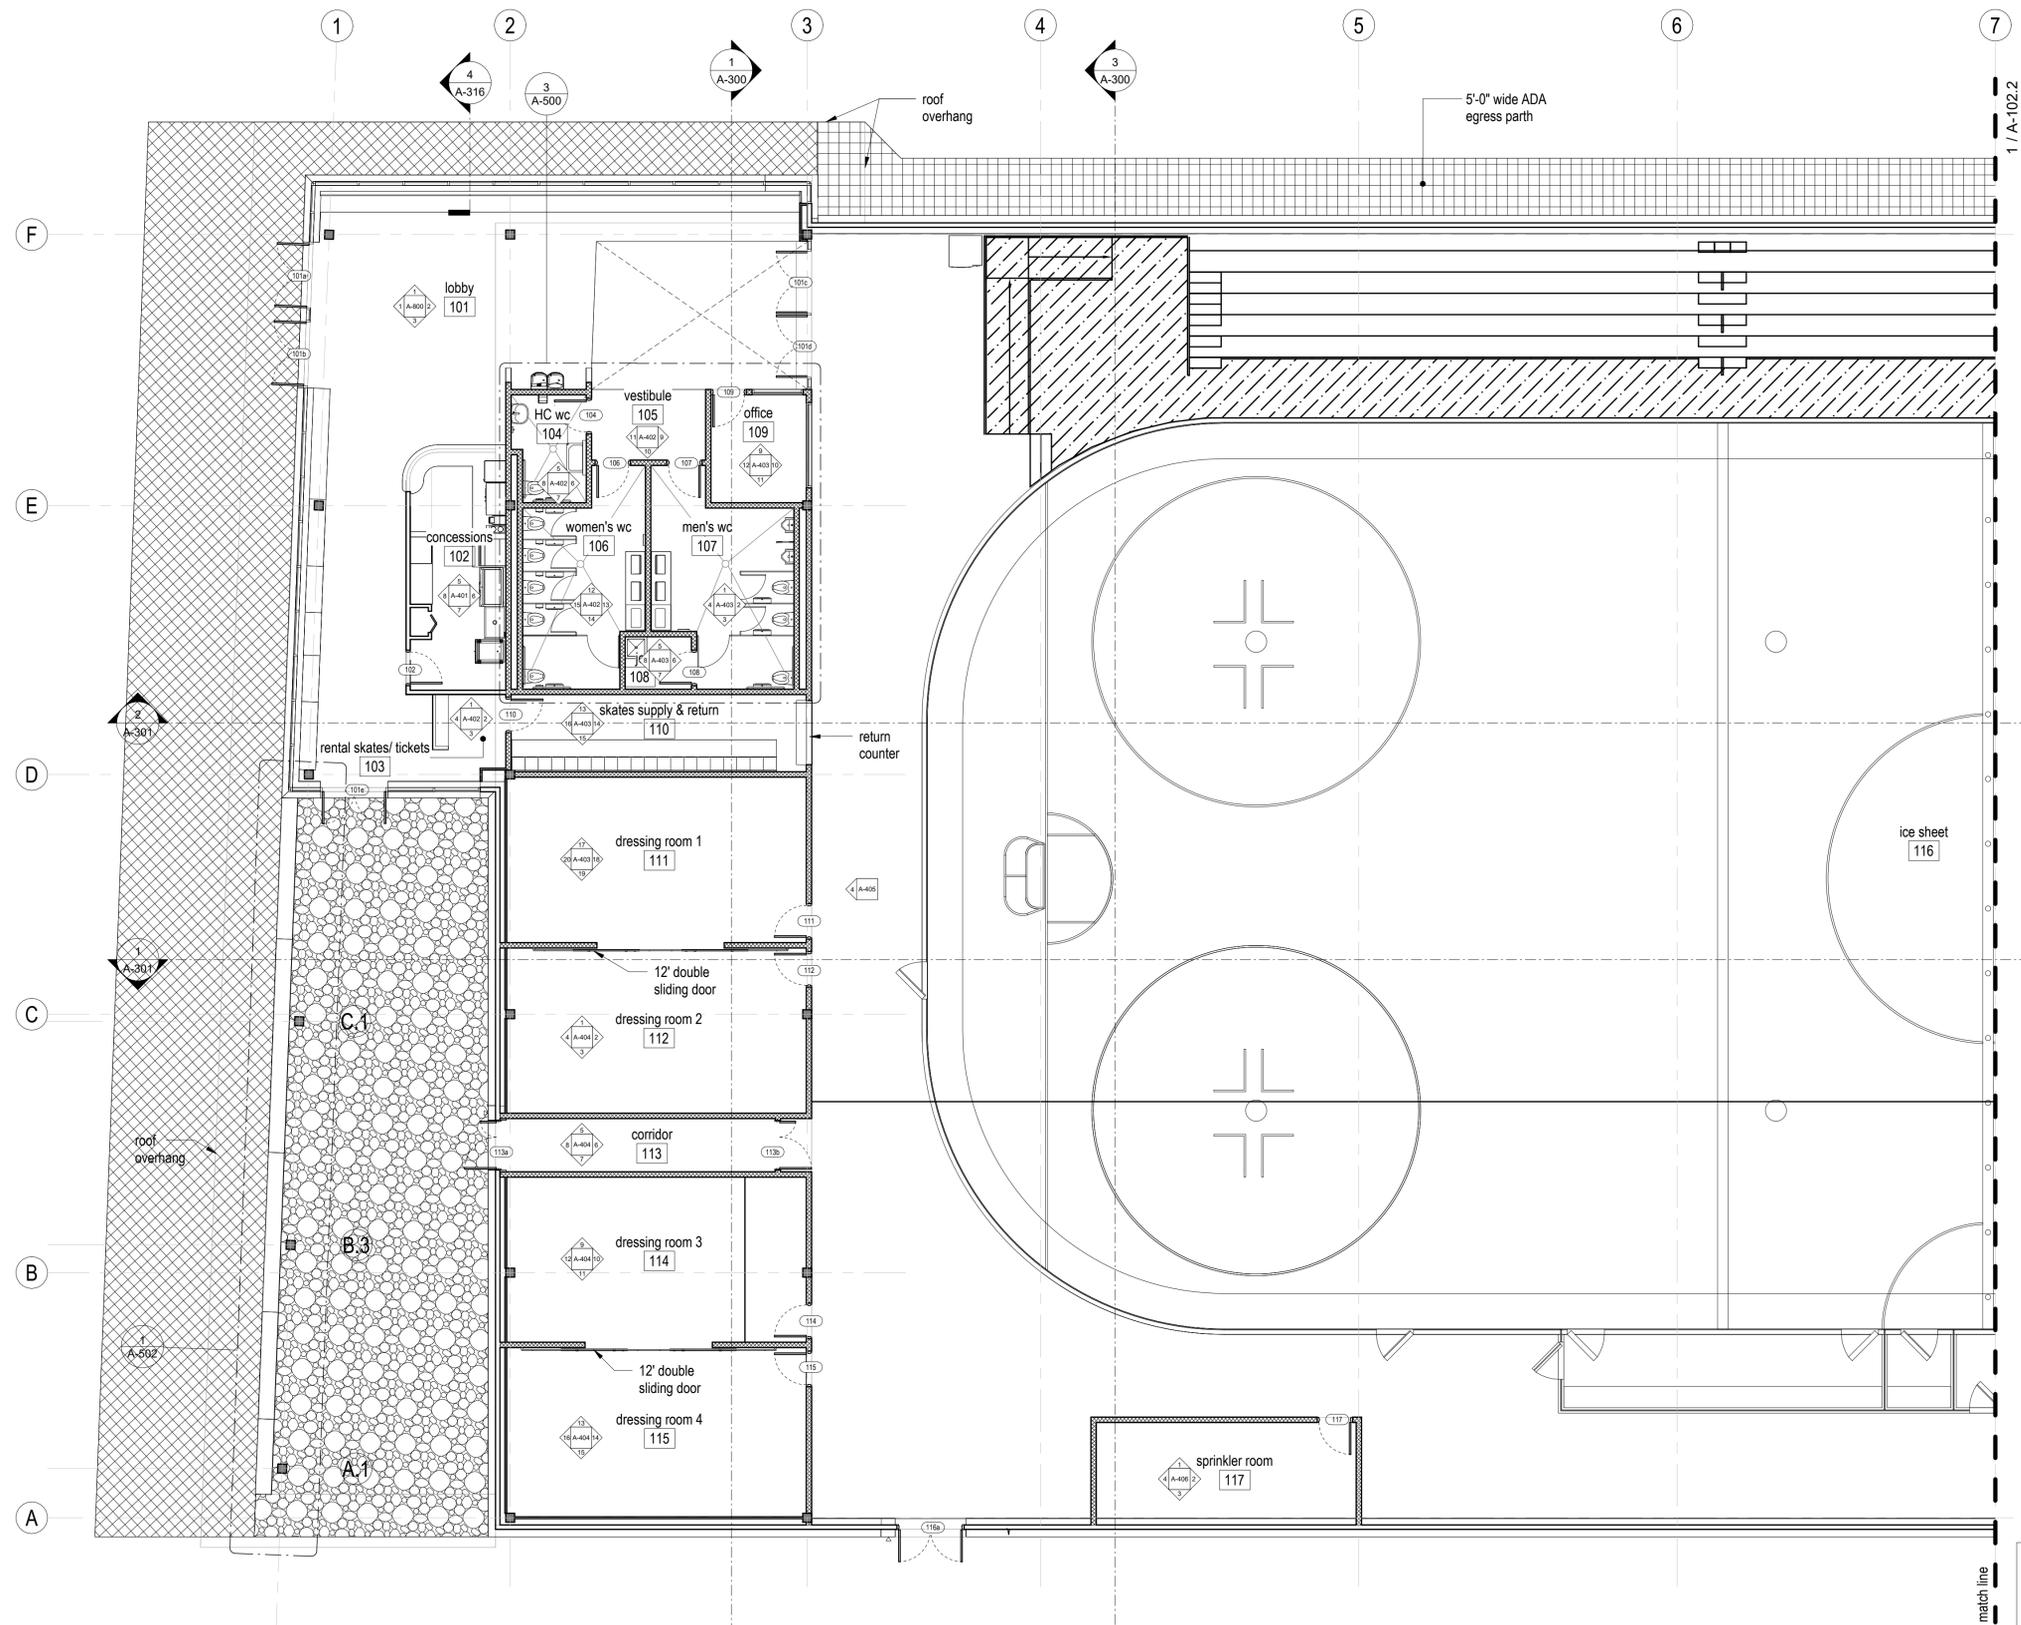

1 1st Floor Plan - South
1/8" = 1'-0"

The Galante Architecture Studio, Inc. expressly reserves the common law copyrights in these drawings. These drawings are not to be reproduced in any manner, nor are they to be assigned to a third party without the expressed written permission and consent of The Galante Architecture Studio, Inc.

 
TGAS

THE GALANTE
ARCHITECTURE
STUDIO INC

146 MT AUBURN ST CAMBRIDGE, MA 02138

6 1 7 5 7 6 2 5 0 0

WWW.GALANTEARCHITECTURE.COM



Project Number
2202

Project Title
Belmont Skating &
Sports Facility

297 Concord Ave,
Belmont, MA 02478

Drawing Title
1st Floor Plan -
North

50% Construction
Documents

Date/Issued For
12.11.2023

**NOT FOR
CONSTRUCTION**


Print 24 x 36

Scale
1/8" = 1'-0"

Drawn By
CT


Drawing Number

A-102.2

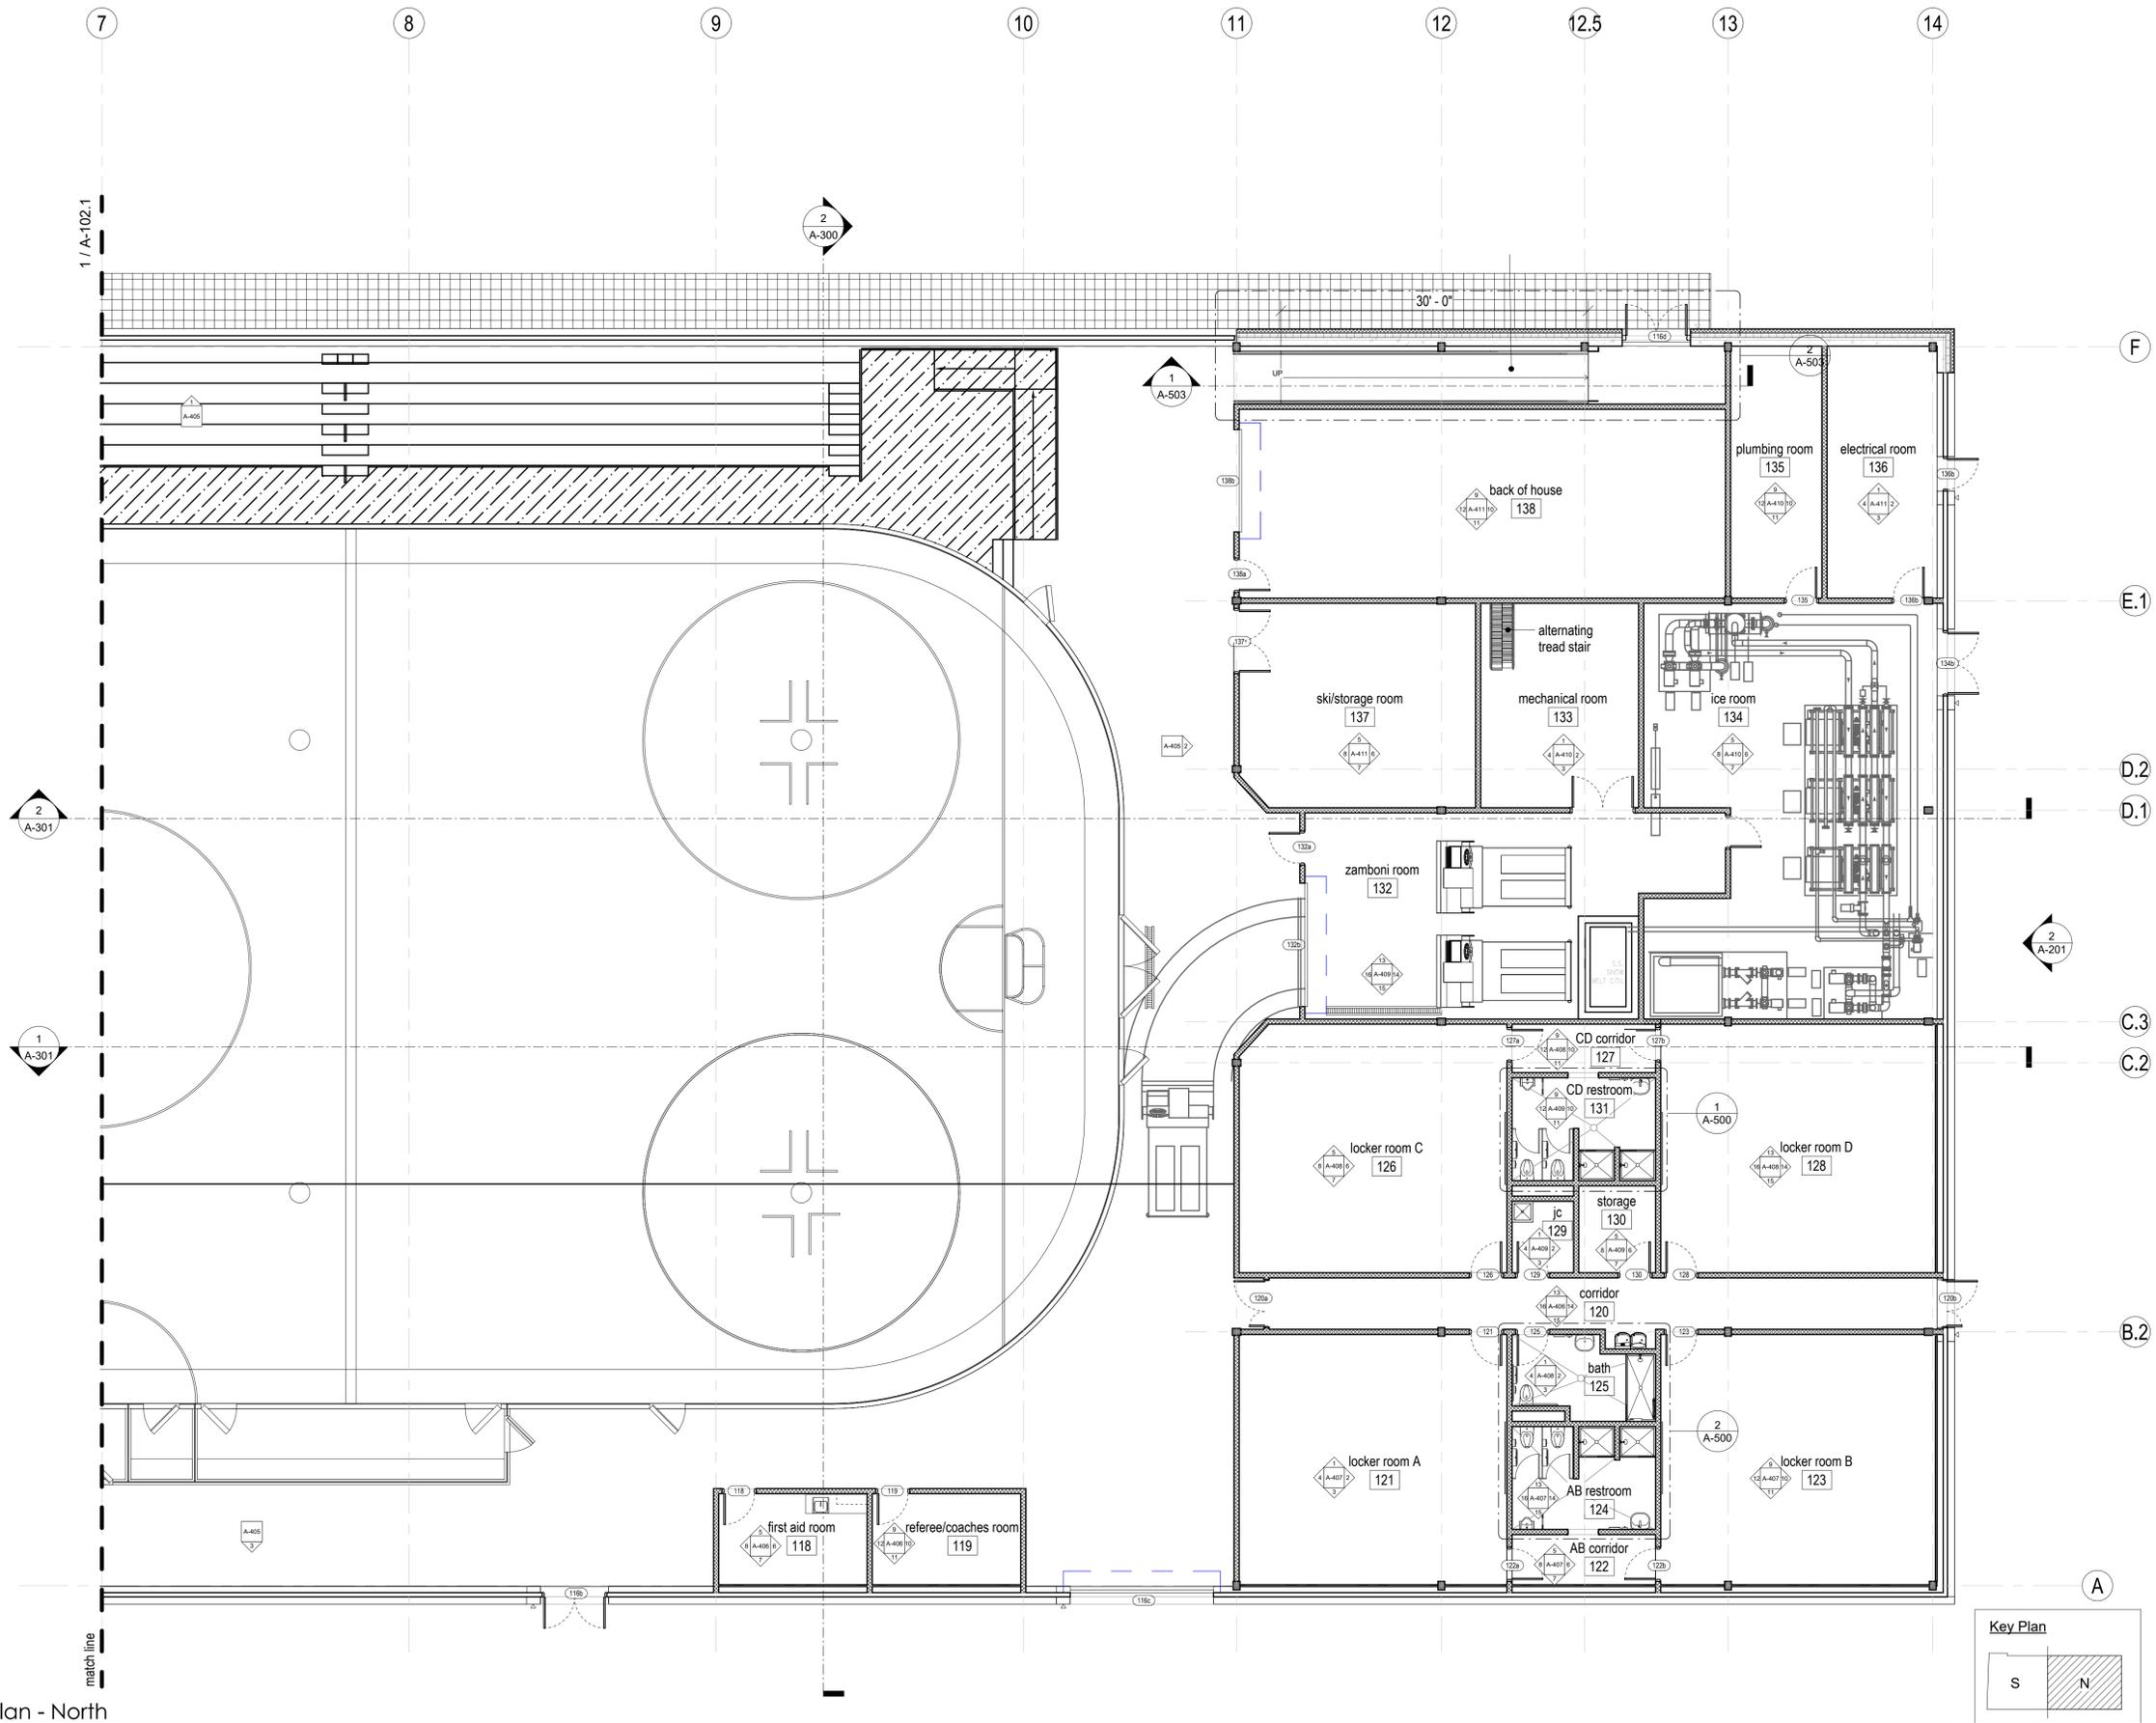

1 1st Floor Plan - North
1/8" = 1'-0"

 The Galante Architecture Studio, Inc. expressly reserves the common law copyrights in these drawings. These drawings are not to be reproduced in any manner, nor are they to be assigned to a third party without the expressed written permission and consent of The Galante Architecture Studio, Inc.



Project Number
2202

Project Title
Belmont Skating &
Sports Facility

297 Concord Ave,
Belmont, MA 02478

Drawing Title
1st Floor
Dimension Plan -
South

50% Construction
Documents

Date/Issued For
12.11.2023

**NOT FOR
CONSTRUCTION**



Print 24 x 36

Scale
1/8" = 1'-0"

Drawn By
CT


Drawing Number

A-103.1

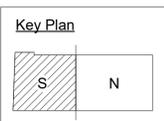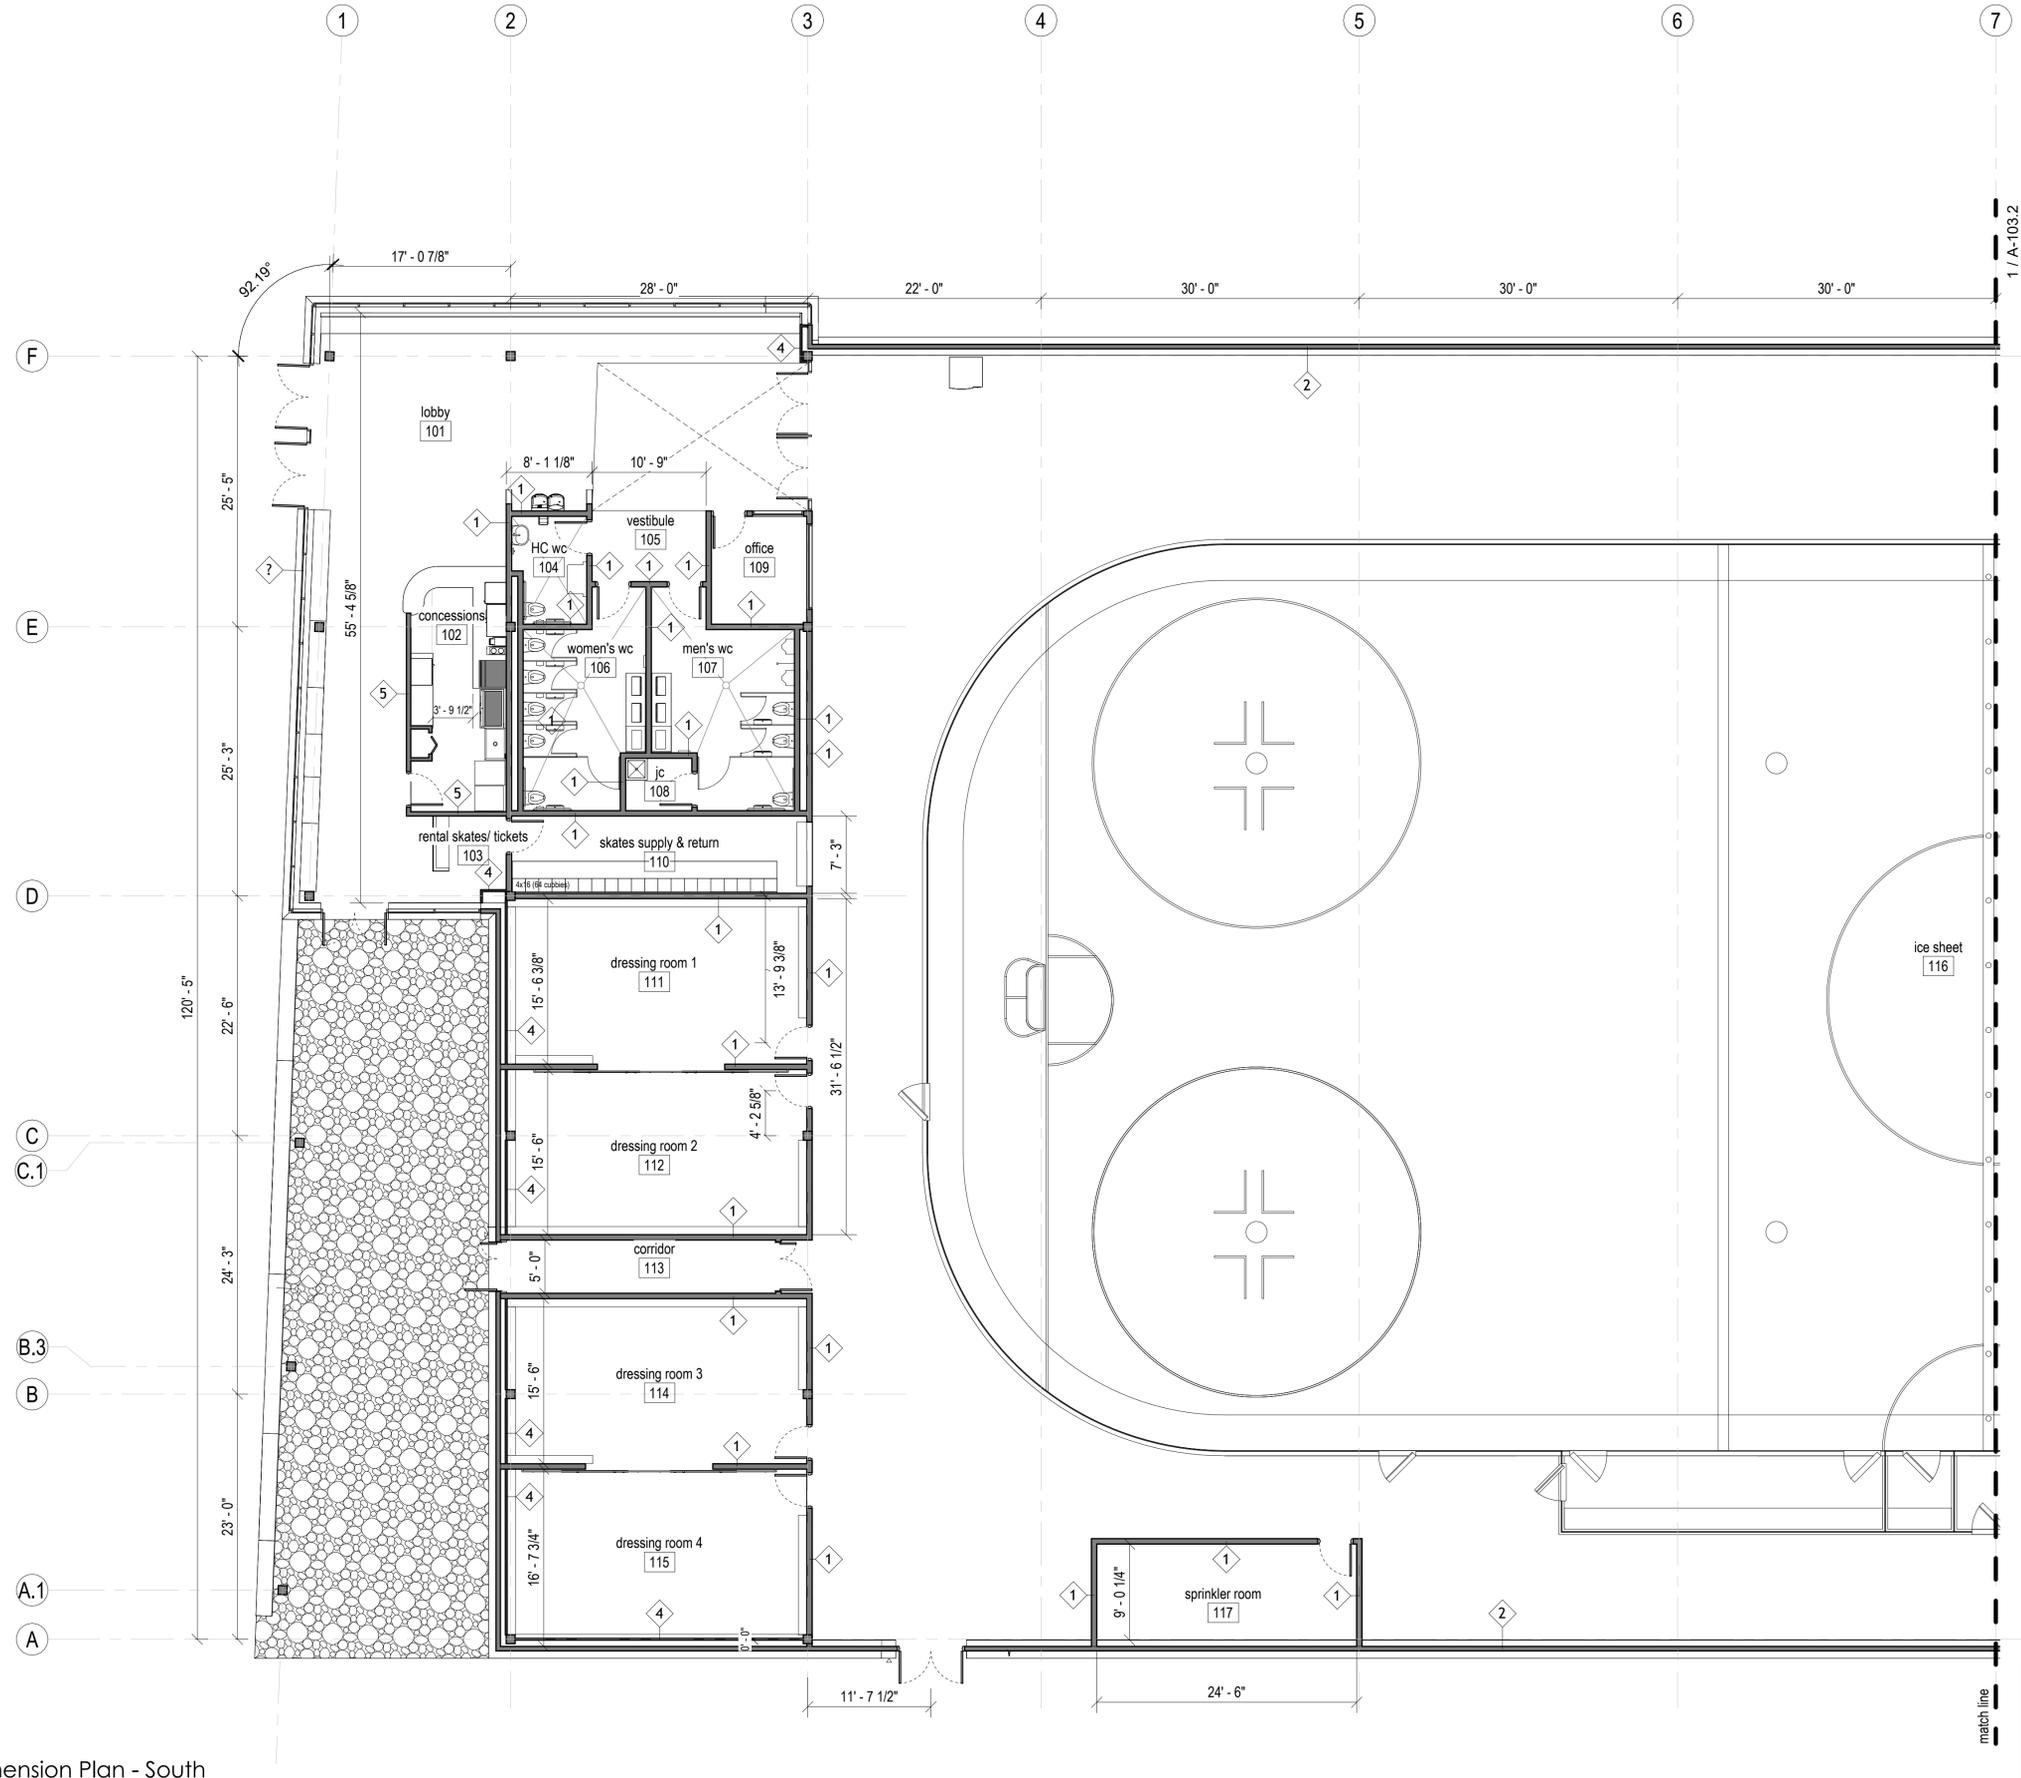

1 1st Floor Dimension Plan - South
1/8" = 1'-0"

The Galante Architecture Studio, Inc. expressly reserves the common law copyrights in these drawings. These drawings are not to be reproduced in any manner, nor are they to be assigned to a third party without the expressed written permission and consent of The Galante Architecture Studio, Inc.

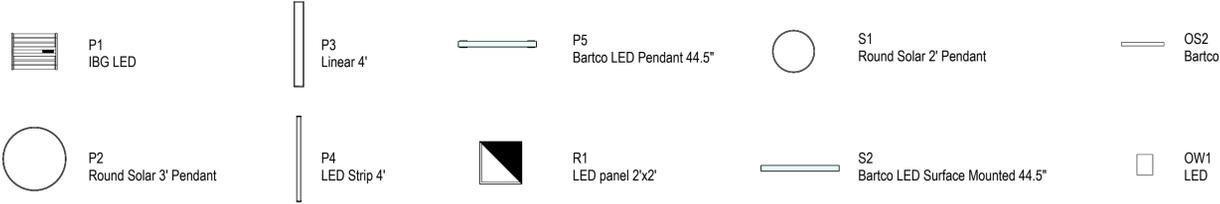

2 Lighting Schedule
1/4" = 1'-0"



1 1st Floor Reflected Ceiling Plan - South
1/8" = 1'-0"

Project Number
2202

Project Title
Belmont Skating &
Sports Facility

297 Concord Ave,
Belmont, MA 02478

Drawing Title
1st Floor Reflected
Ceiling Plan -
South

50% Construction
Documents

Date/Issued For
12.11.2023

**NOT FOR
CONSTRUCTION**

Print 24 x 36


Scale
As indicated

Drawn By
CT


Drawing Number

A-104.1


The Galante Architecture Studio, Inc. expressly reserves the common law copyrights in these drawings. These drawings are not to be reproduced in any manner, nor are they to be assigned to a third party without the expressed written permission and consent of The Galante Architecture Studio, Inc.

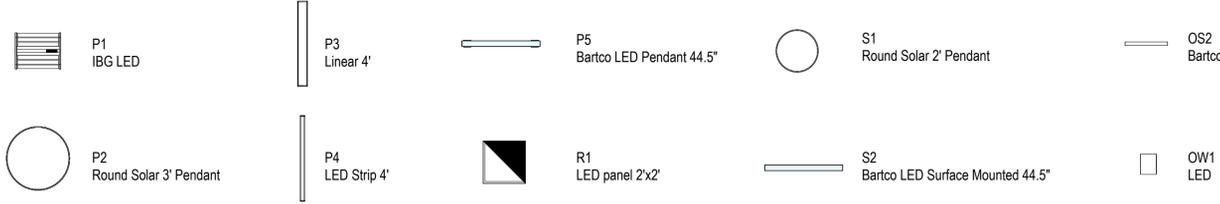

2 Lighting Schedule
1/4" = 1'-0"

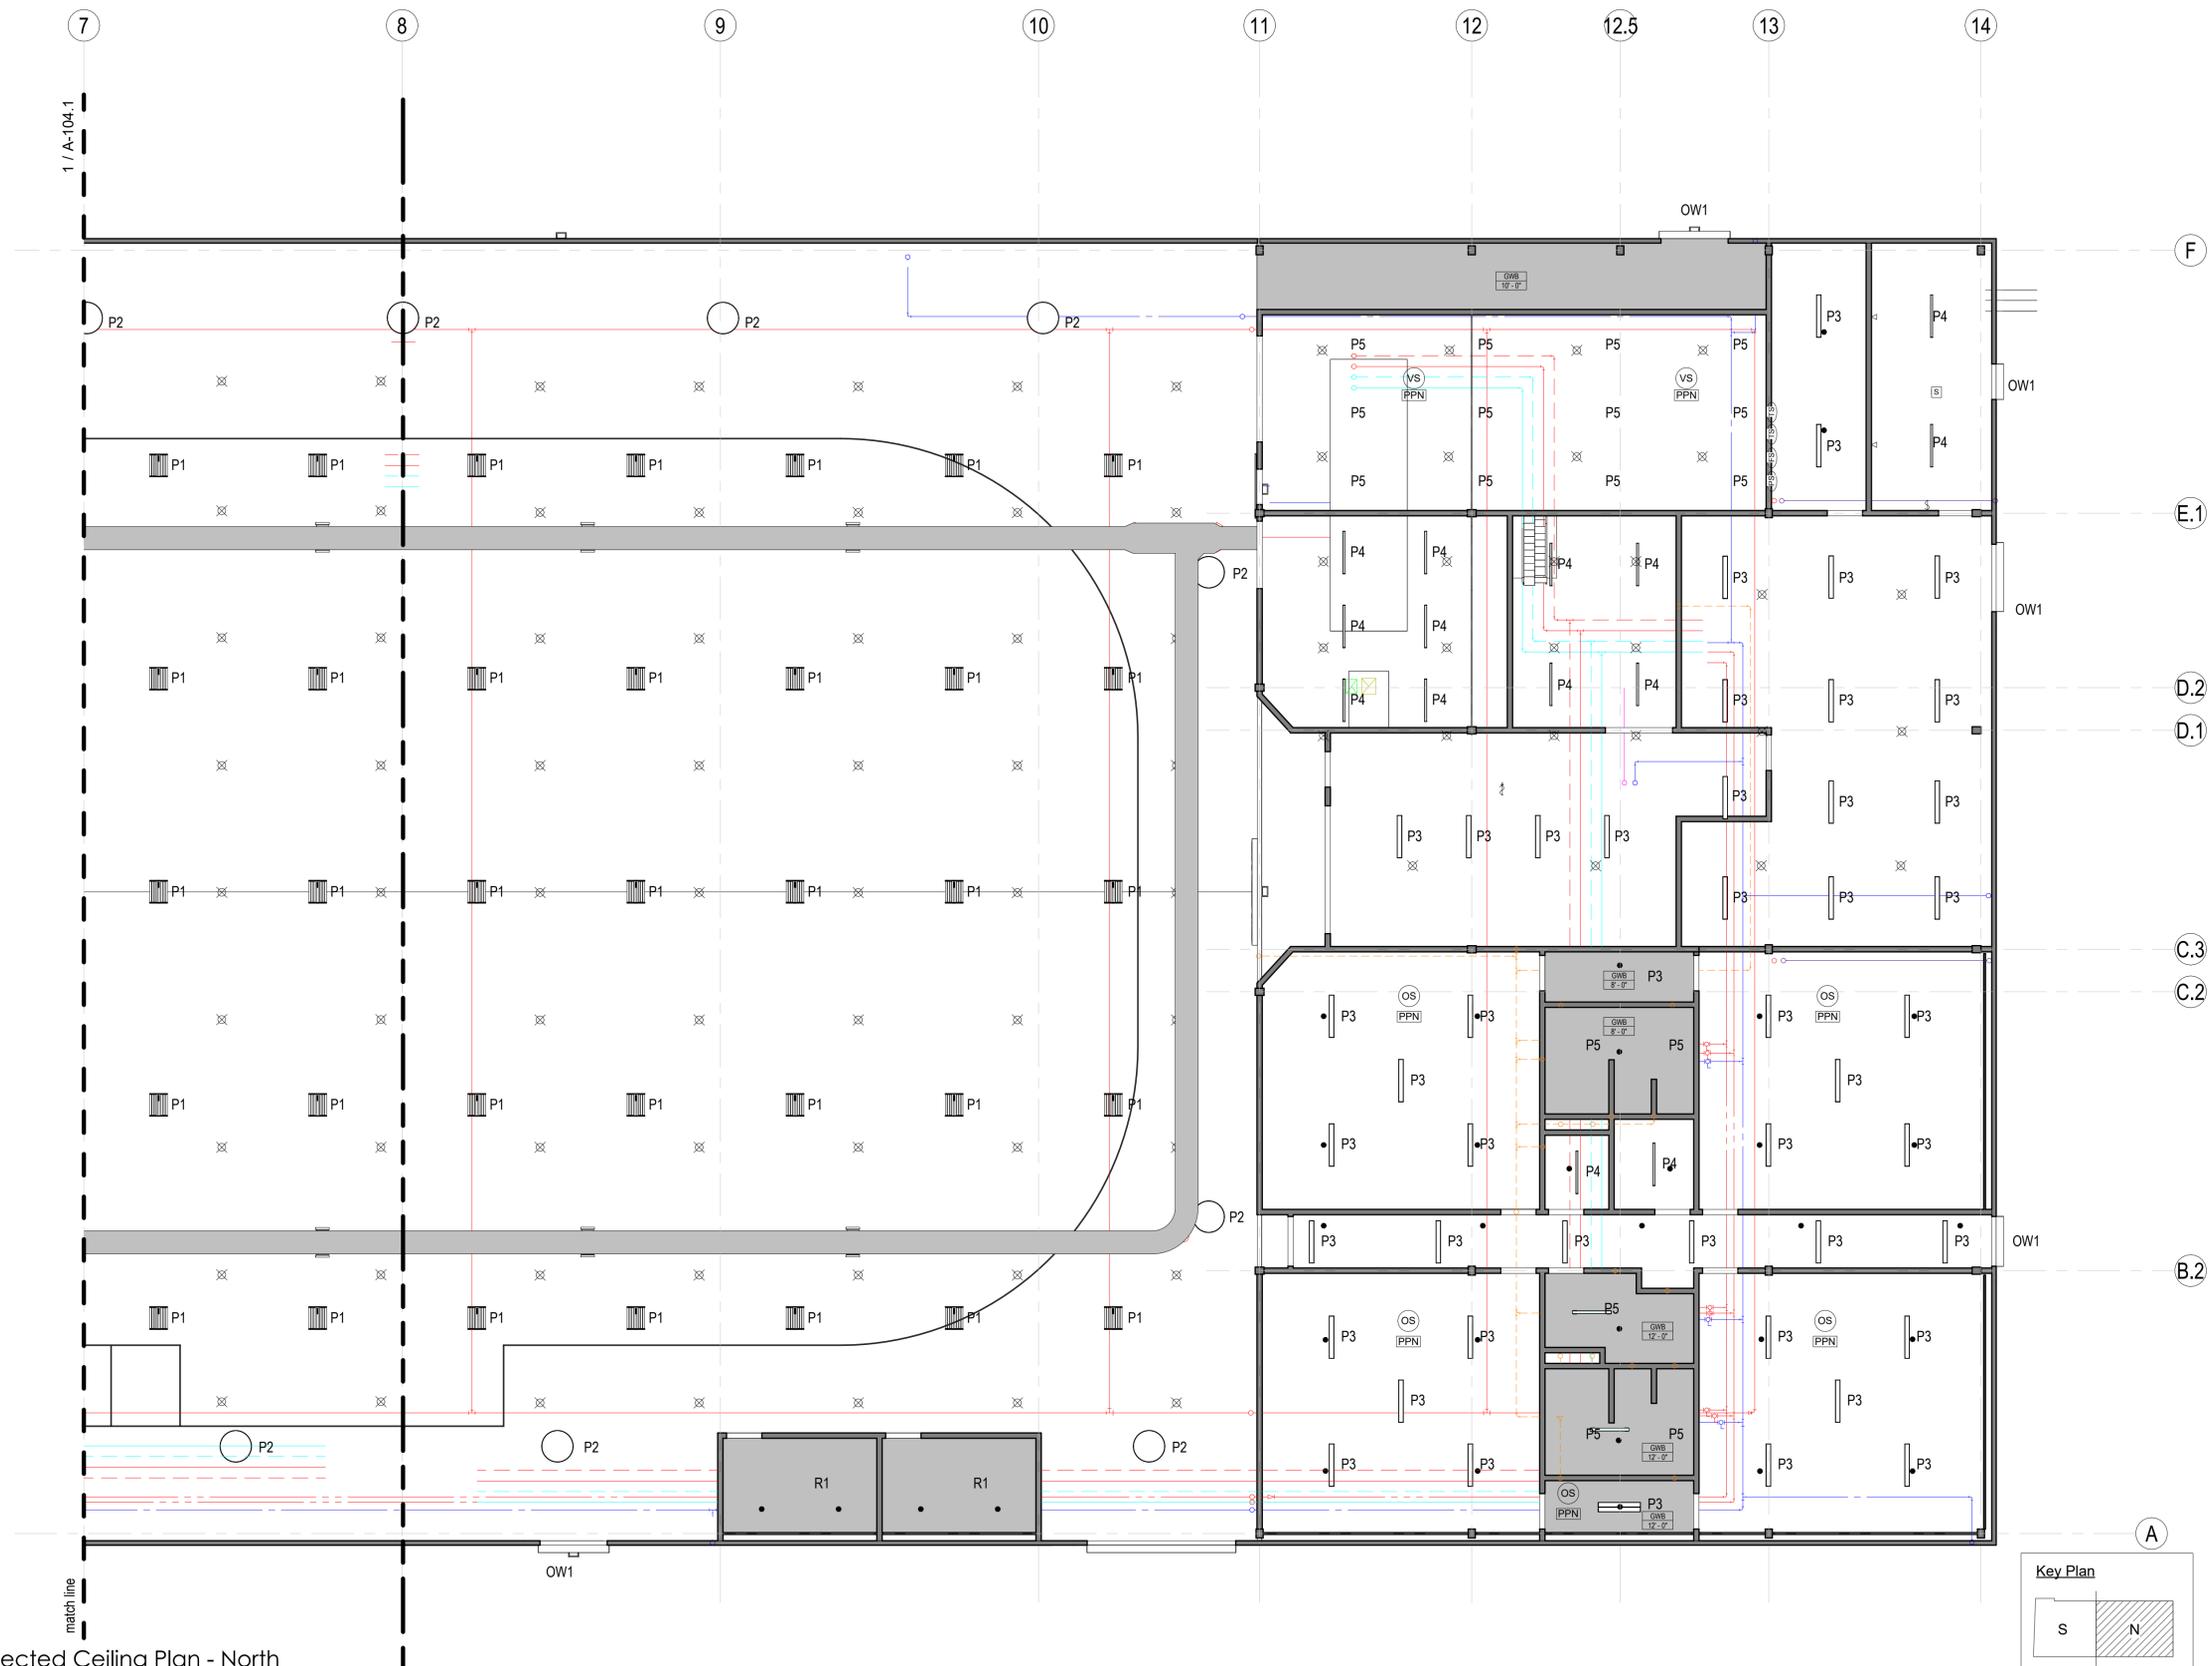

1 1st Floor Reflected Ceiling Plan - North
1/8" = 1'-0"

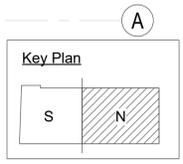

Project Number
 2202
 Project Title
 Belmont Skating &
 Sports Facility

297 Concord Ave,
 Belmont, MA 02478

Drawing Title
 1st Floor Reflected
 Ceiling Plan -
 North

50% Construction
 Documents

Date/Issued For
 12.11.2023

**NOT FOR
 CONSTRUCTION**

Scale
 As indicated

Drawn By
 CT

Drawing Number
A-104.2

Print 24 x 36



Project Number
2202

Project Title
Belmont Skating &
Sports Facility

297 Concord Ave,
Belmont, MA 02478

Drawing Title
Roof Plan - South

50% Construction
Documents

Date/Issued For
12.11.2023


**NOT FOR
CONSTRUCTION**

Print 24 x 36


Scale
1/8" = 1'-0"

Drawn By
CT

Drawing Number
A-105.1

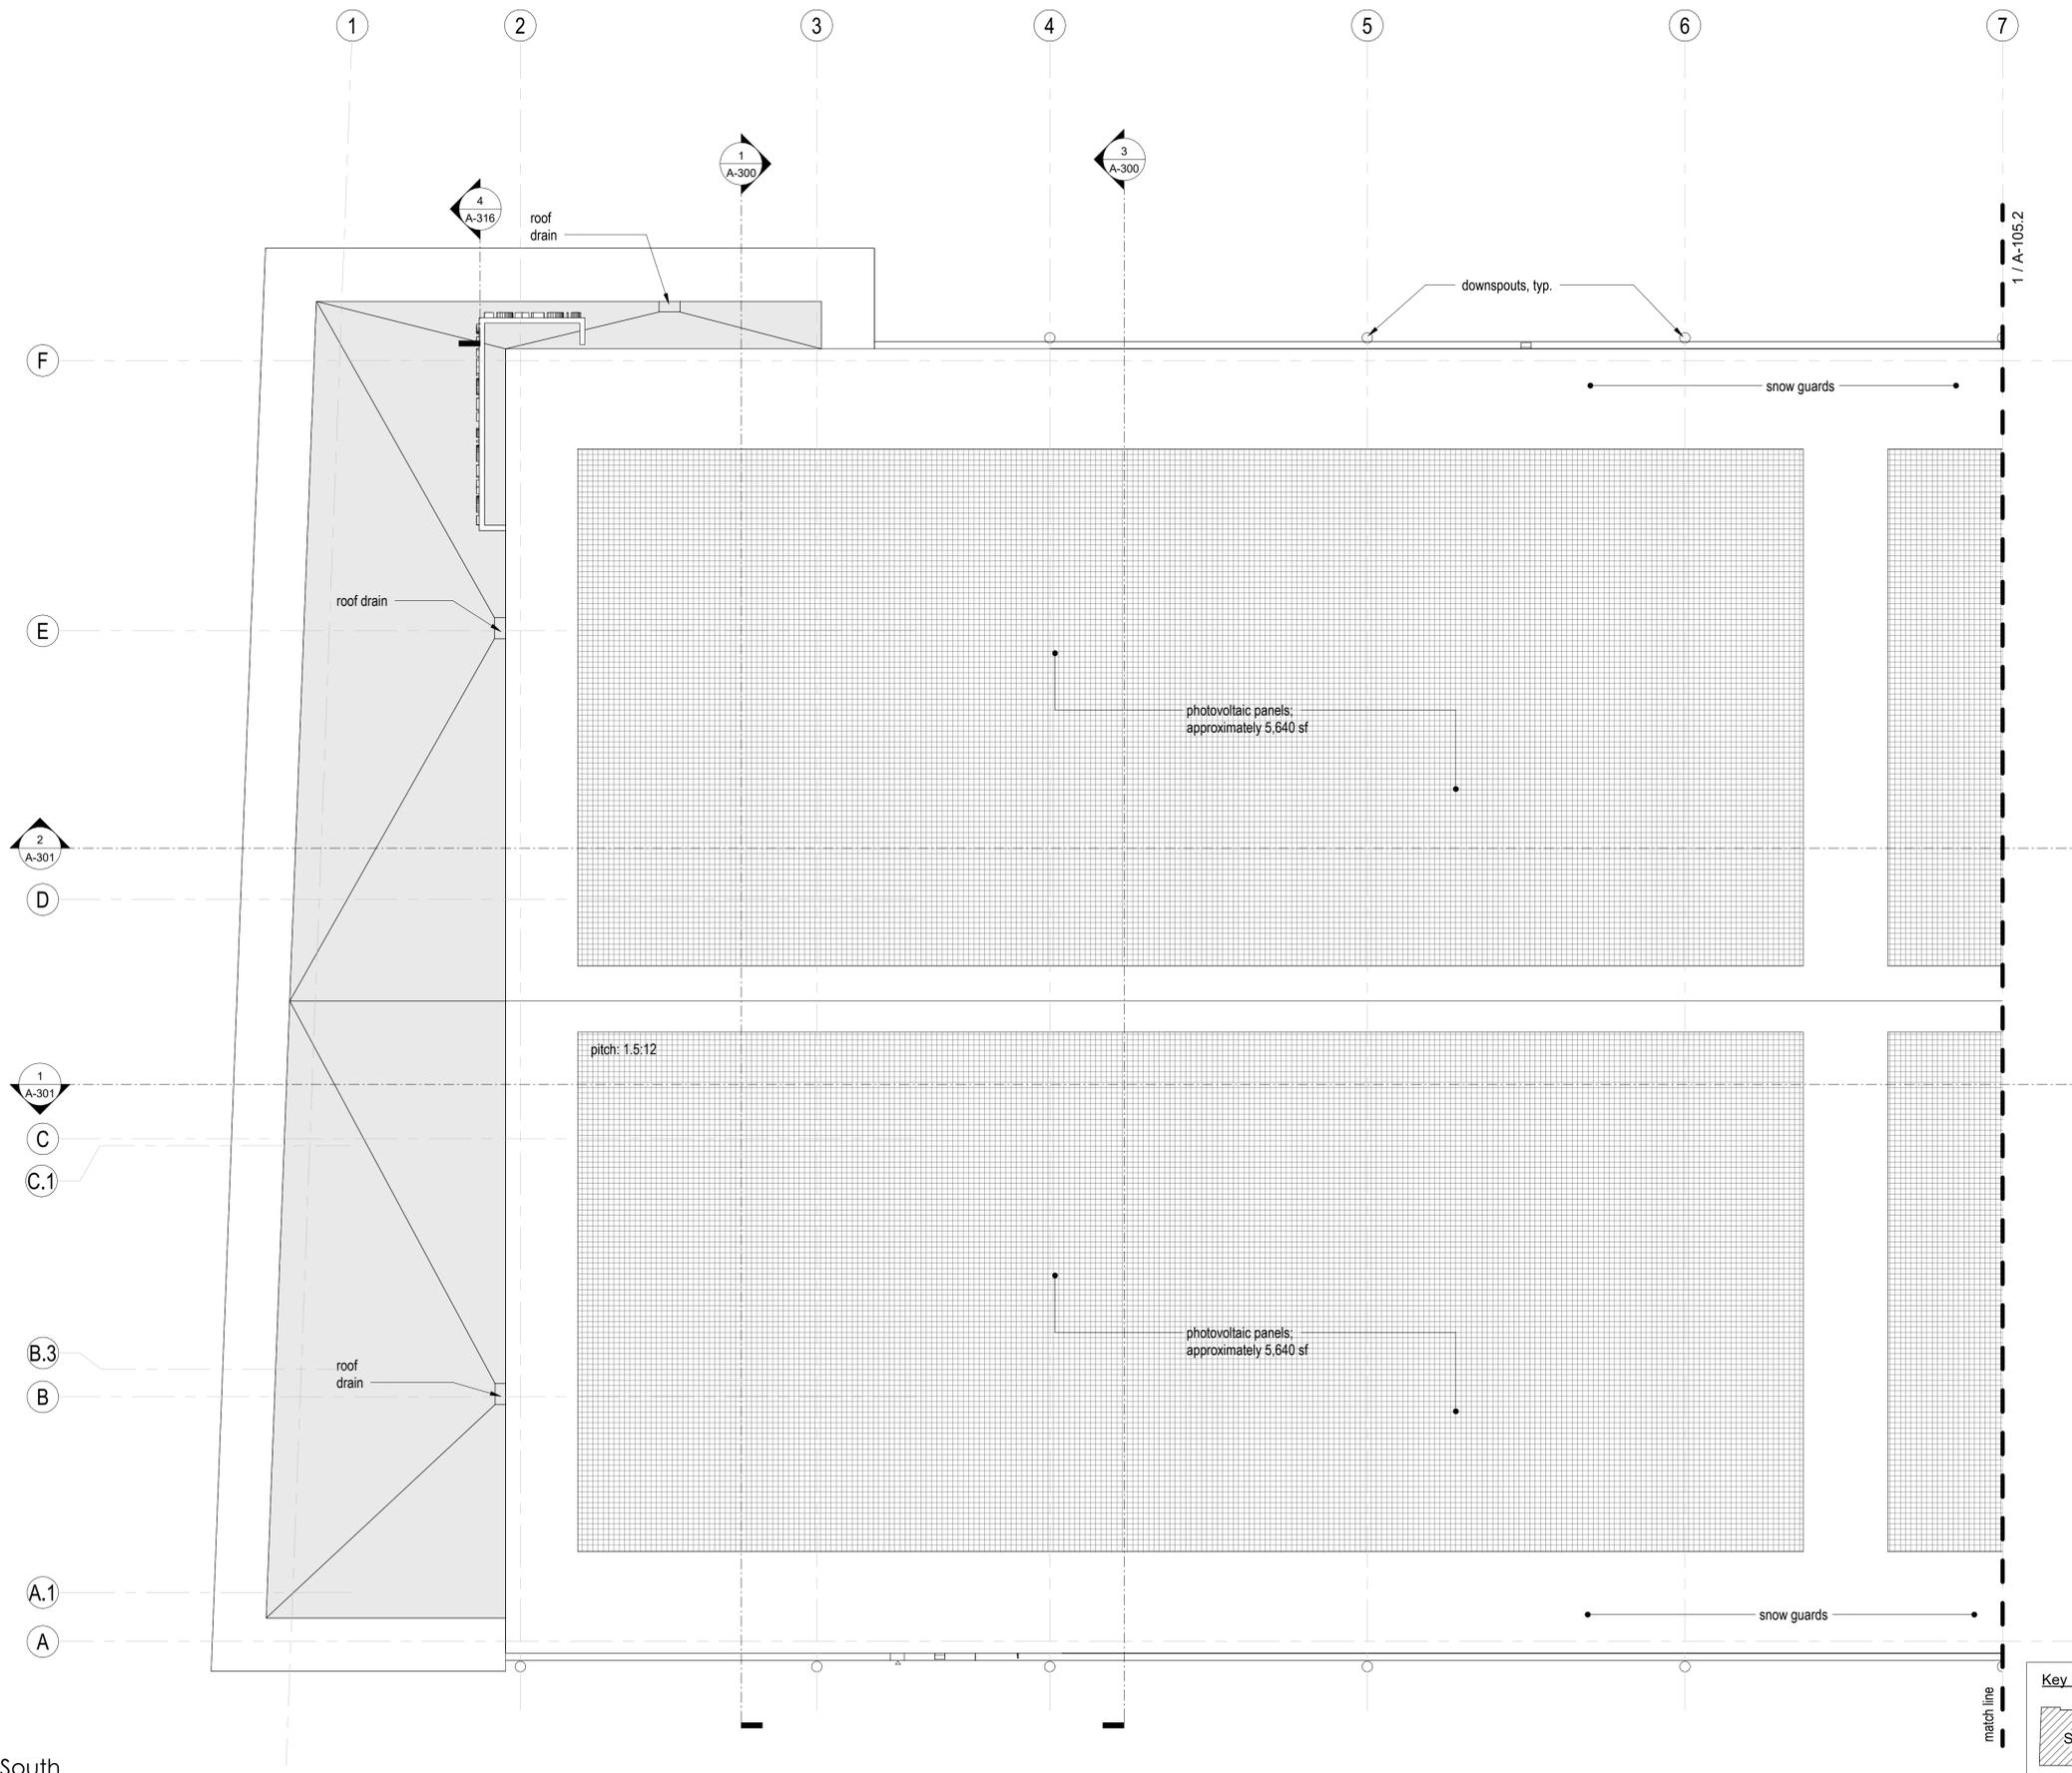

1 Roof Plan - South
1/8" = 1'-0"

 

Project Number
2202

Project Title
Belmont Skating &
Sports Facility

297 Concord Ave,
Belmont, MA 02478

Drawing Title
Roof Plan - North

50% Construction
Documents

Date/Issued For
12.11.2023

**NOT FOR
CONSTRUCTION**


Print 24 x 36

Scale
1/8" = 1'-0"


Drawn By
CT

Drawing Number

A-105.2

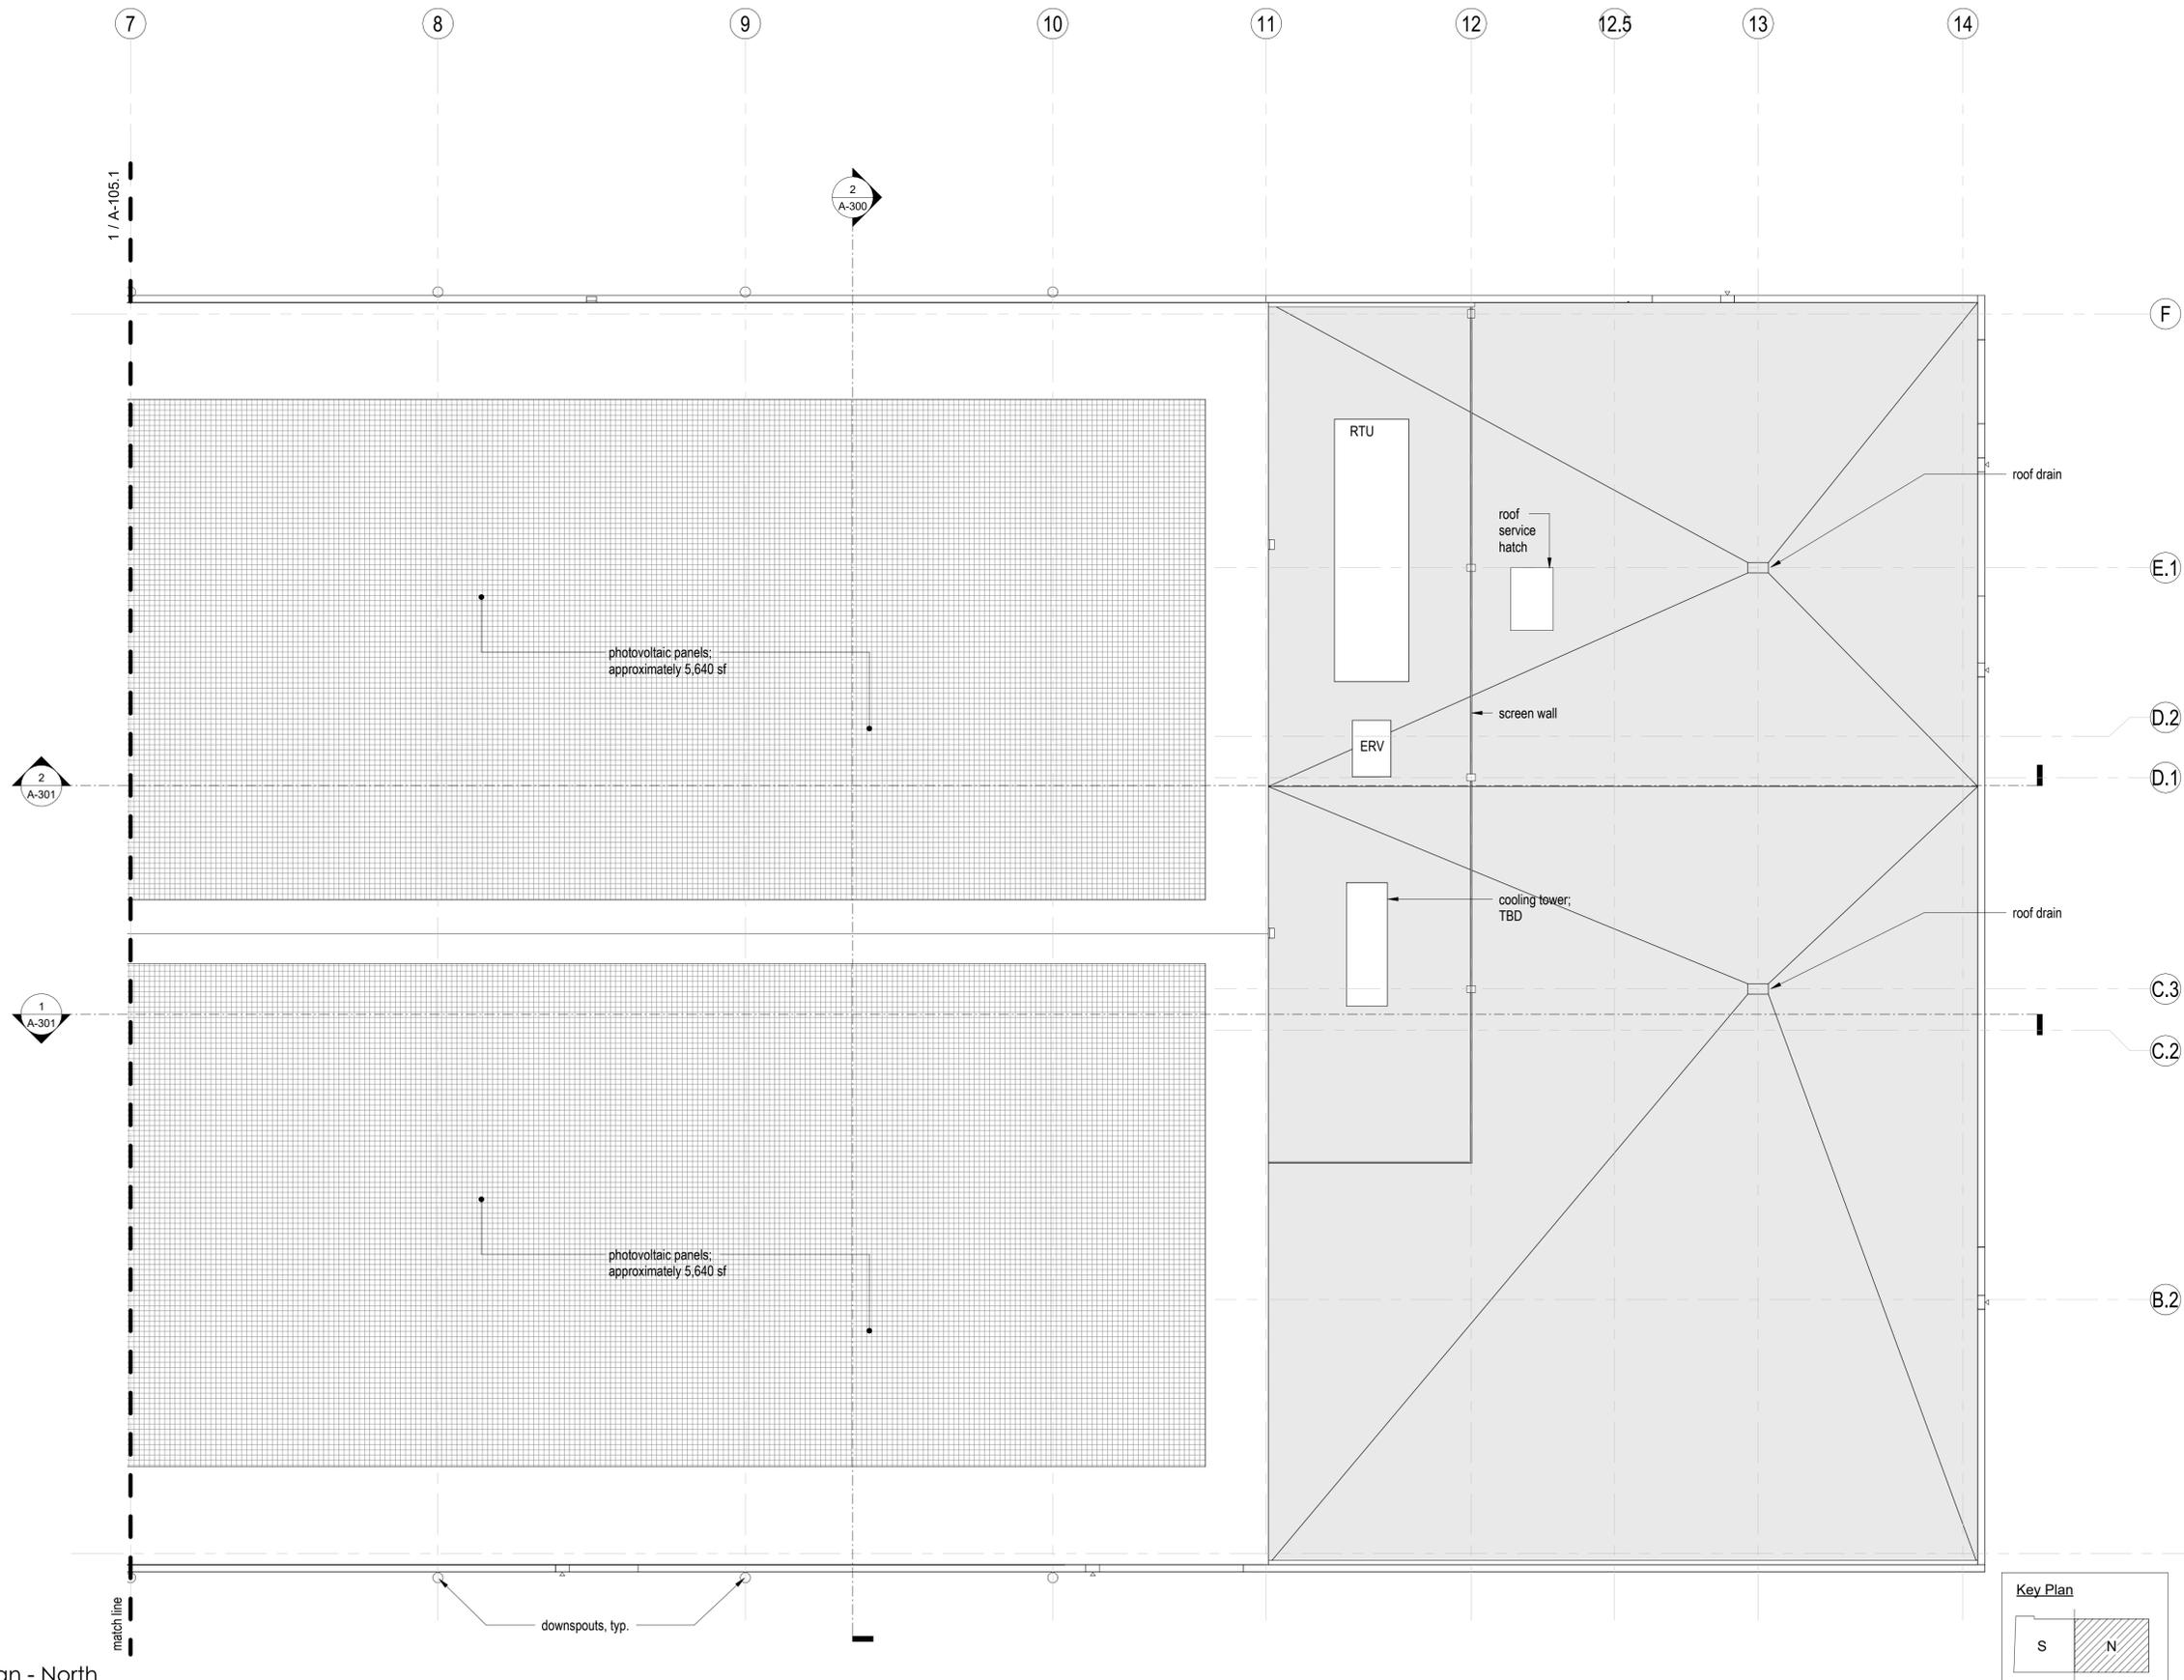

1 Roof Plan - North
1/8" = 1'-0"

 

Project Number
2202

Project Title
Belmont Skating &
Sports Facility

297 Concord Ave,
Belmont, MA 02478

Drawing Title
Roof Dimension
Plan - South

50% Construction
Documents

Date/Issued For
12.11.2023

**NOT FOR
CONSTRUCTION**

 

Print 24 x 36

Scale
1/8" = 1'-0"

Drawn By
CT


Drawing Number

A-106.1

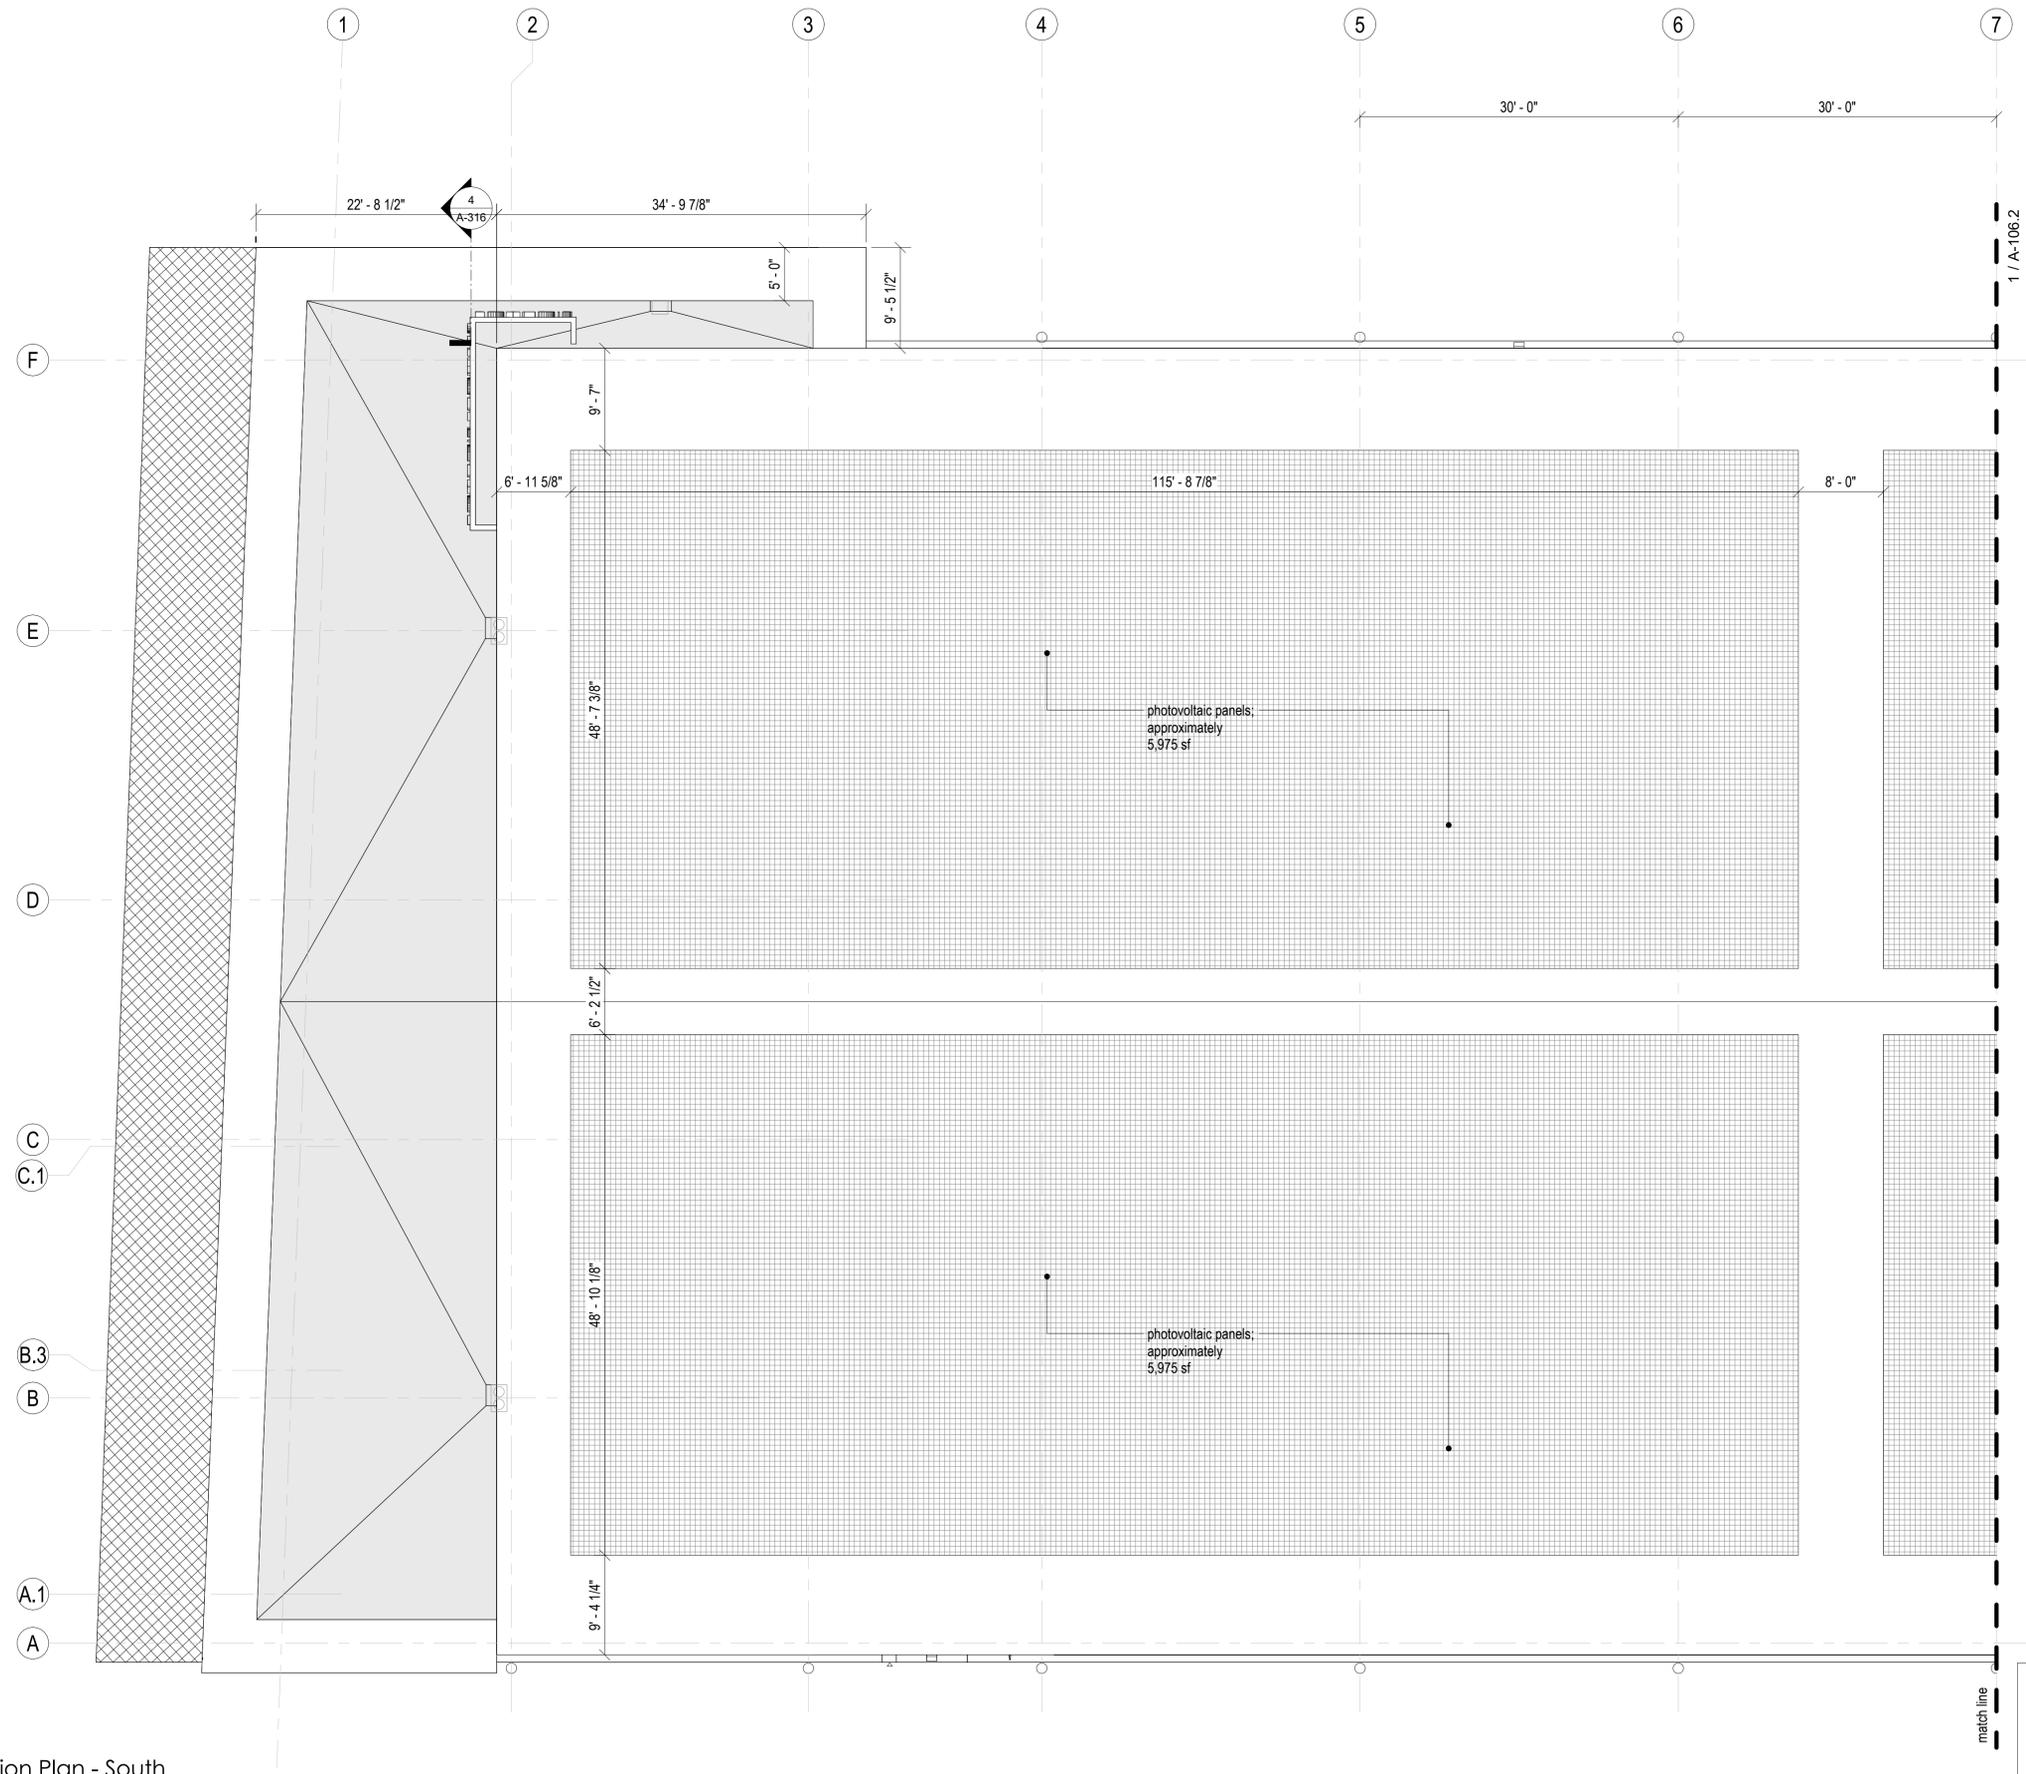

1 Roof Dimension Plan - South
1/8" = 1'-0"

 The Galante Architecture Studio, Inc. expressly reserves the common law copyrights in these drawings. These drawings are not to be reproduced in any manner, nor are they to be assigned to a third party without the expressed written permission and consent of The Galante Architecture Studio, Inc.



Project Number
2202

Project Title
Belmont Skating &
Sports Facility

297 Concord Ave,
Belmont, MA 02478

Drawing Title
Roof Dimension
Plan - North

50% Construction
Documents

Date/Issued For
12.11.2023

**NOT FOR
CONSTRUCTION**


Print 24 x 36

Scale
1/8" = 1'-0"


Drawn By
CT

Drawing Number


A-106.2

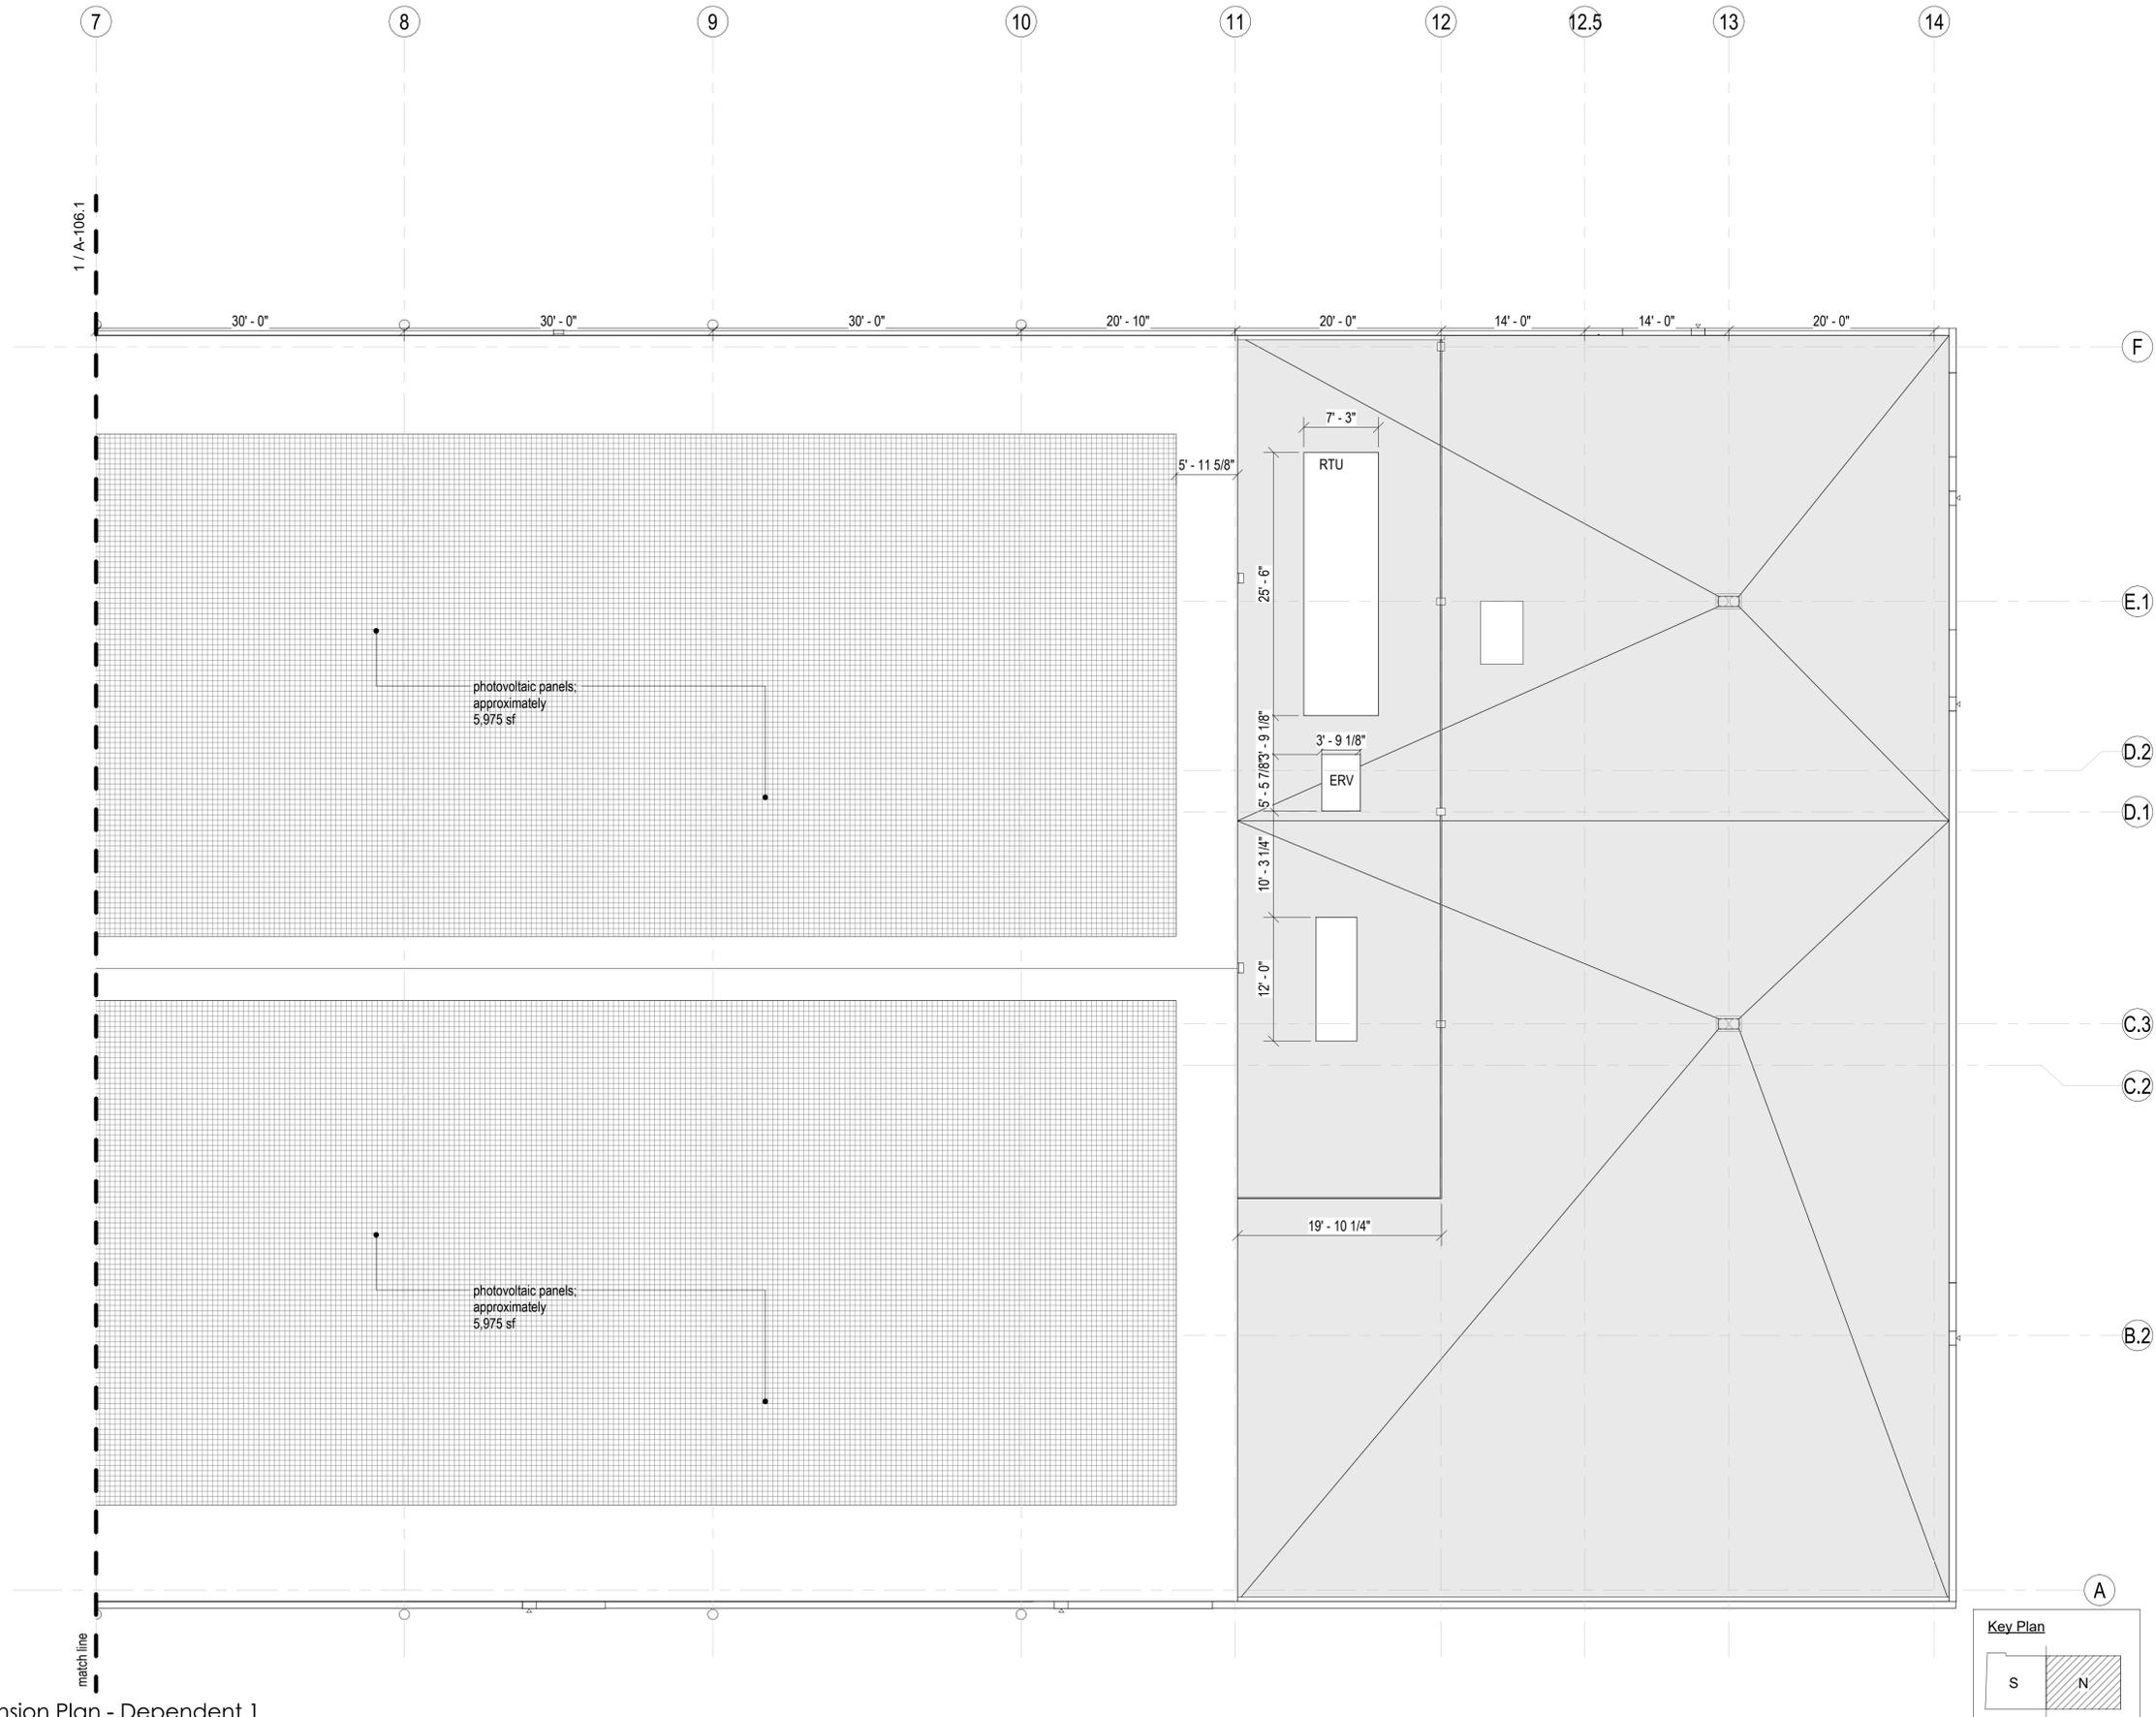

1 Roof Dimension Plan - Dependent 1
1/8" = 1'-0"

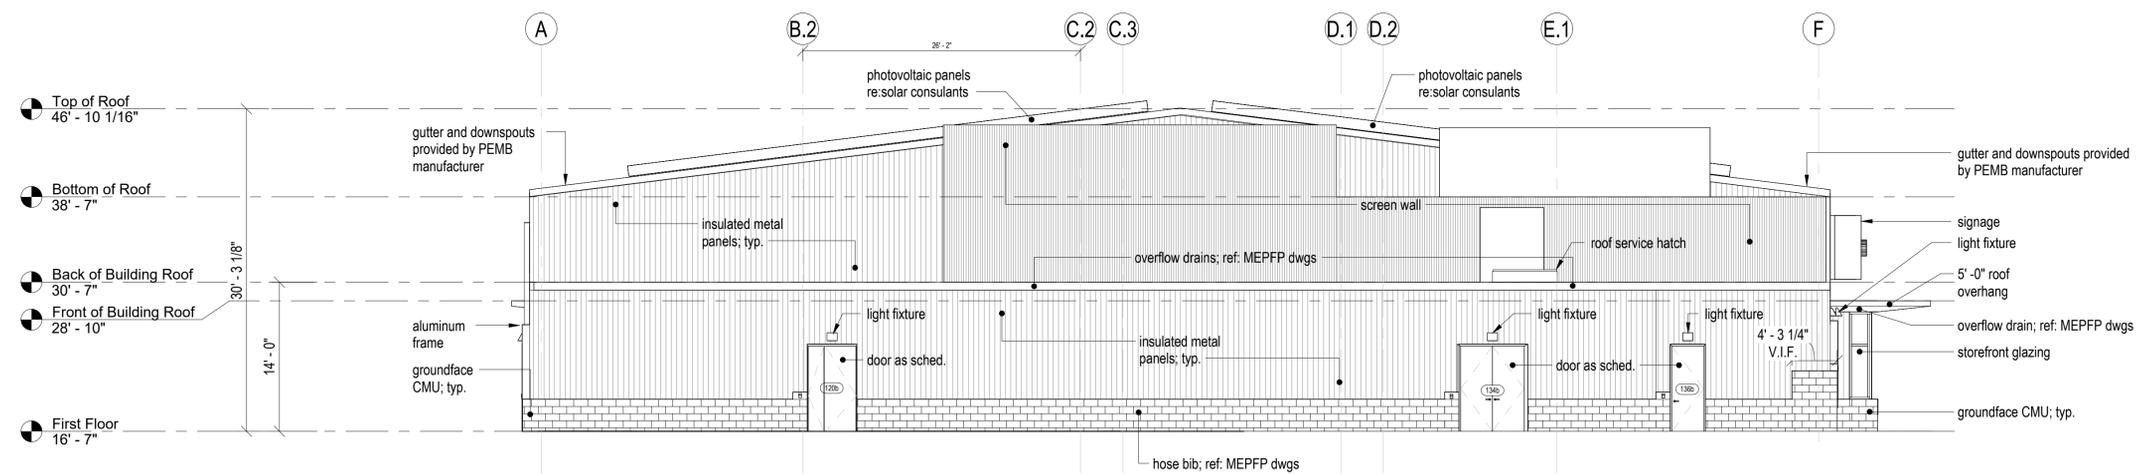

2 North Building Elevation
1/8" = 1'-0"

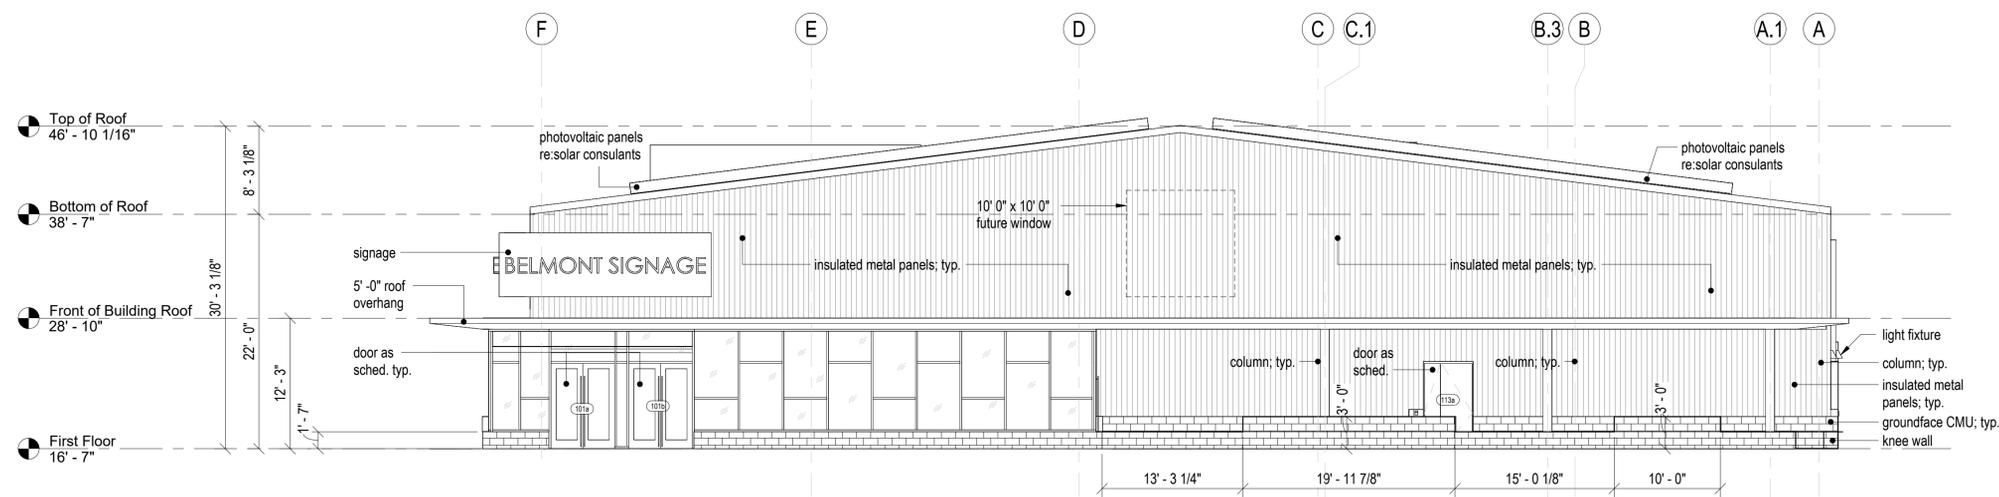

1 South Building Elevation
1/8" = 1'-0"

Project Number
2202
Project Title
Belmont Skating & Sports Facility

297 Concord Ave,
Belmont, MA 02478

Drawing Title
Building Elevations

50% Construction Documents

Date/Issued For
12.11.2023



NOT FOR CONSTRUCTION

Scale
1/8" = 1'-0"

Drawn By
CT

Drawing Number

A-201

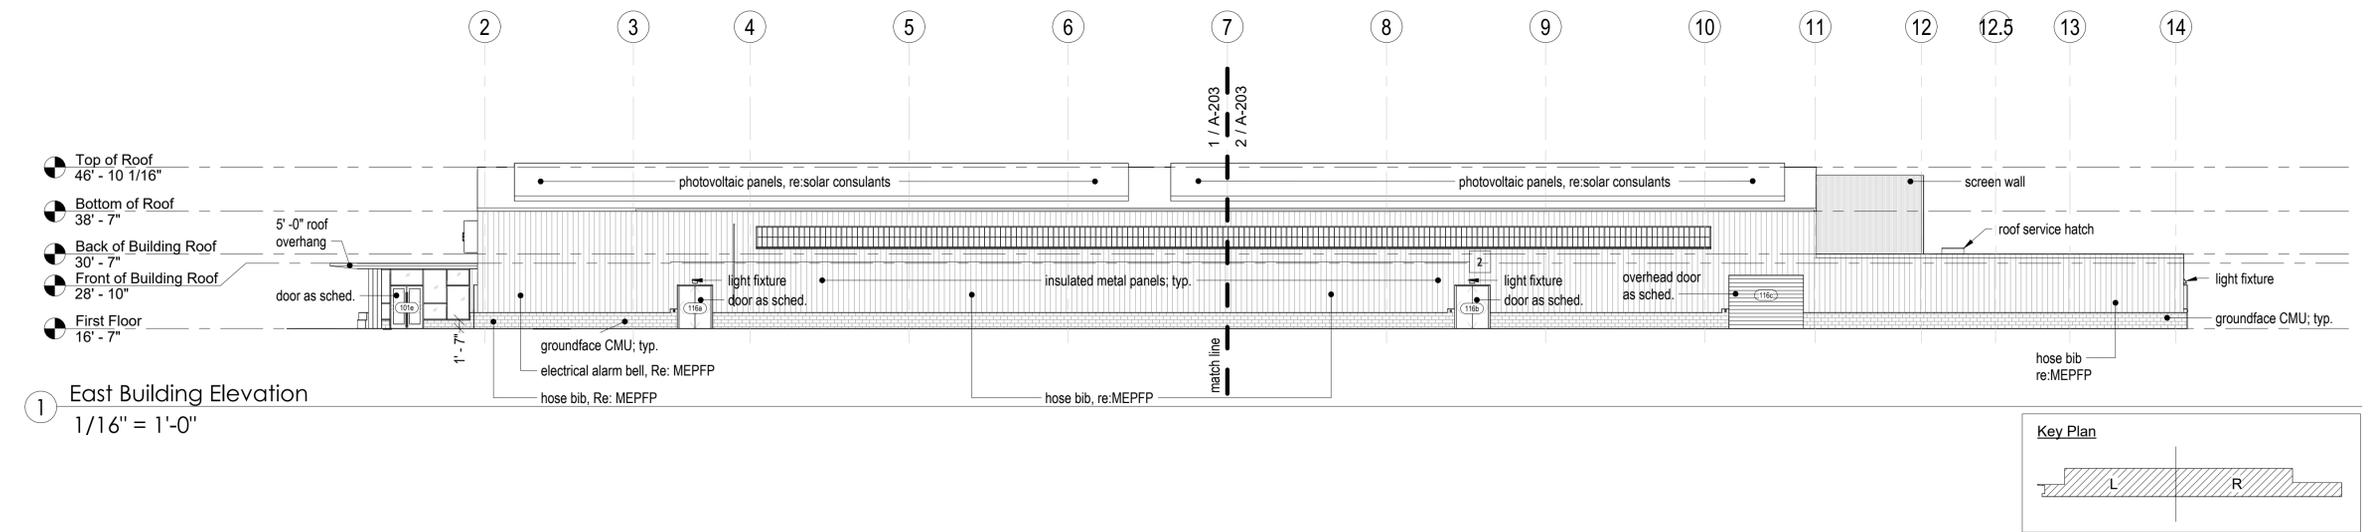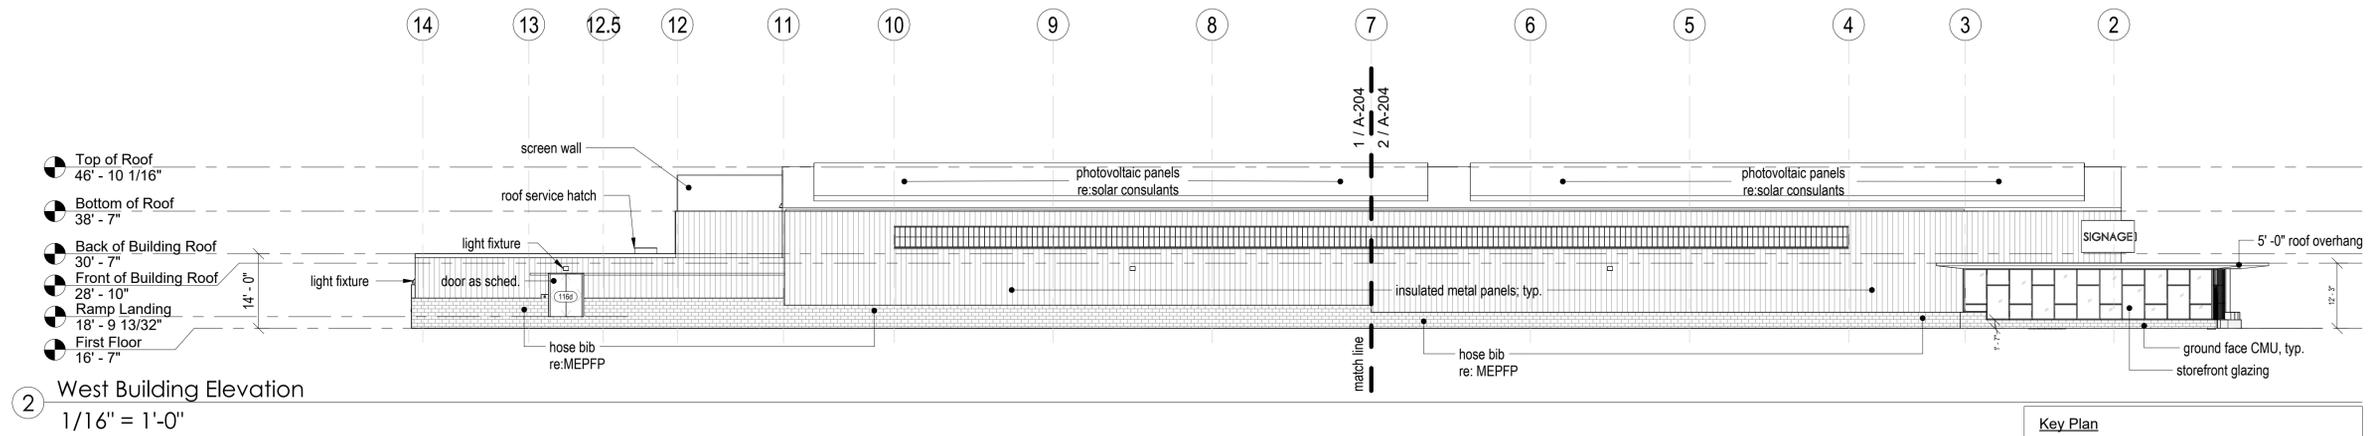

Project Number
2202

Project Title
Belmont Skating & Sports Facility

297 Concord Ave,
Belmont, MA 02478

Drawing Title
Building Elevations

50% Construction
Documents

Date/Issued For
12.11.2023

**NOT FOR
CONSTRUCTION**

Scale
1/16" = 1'-0"

Drawn By
CT

Drawing Number
A-202

Project Number
2202

Project Title
Belmont Skating &
Sports Facility

297 Concord Ave,
Belmont, MA 02478

Drawing Title
East Building
Elevations

50% Construction
Documents

Date/Issued For
12.11.2023


**NOT FOR
CONSTRUCTION**

Scale
1/8" = 1'-0"



Drawn By
CT

Drawing Number


A-203

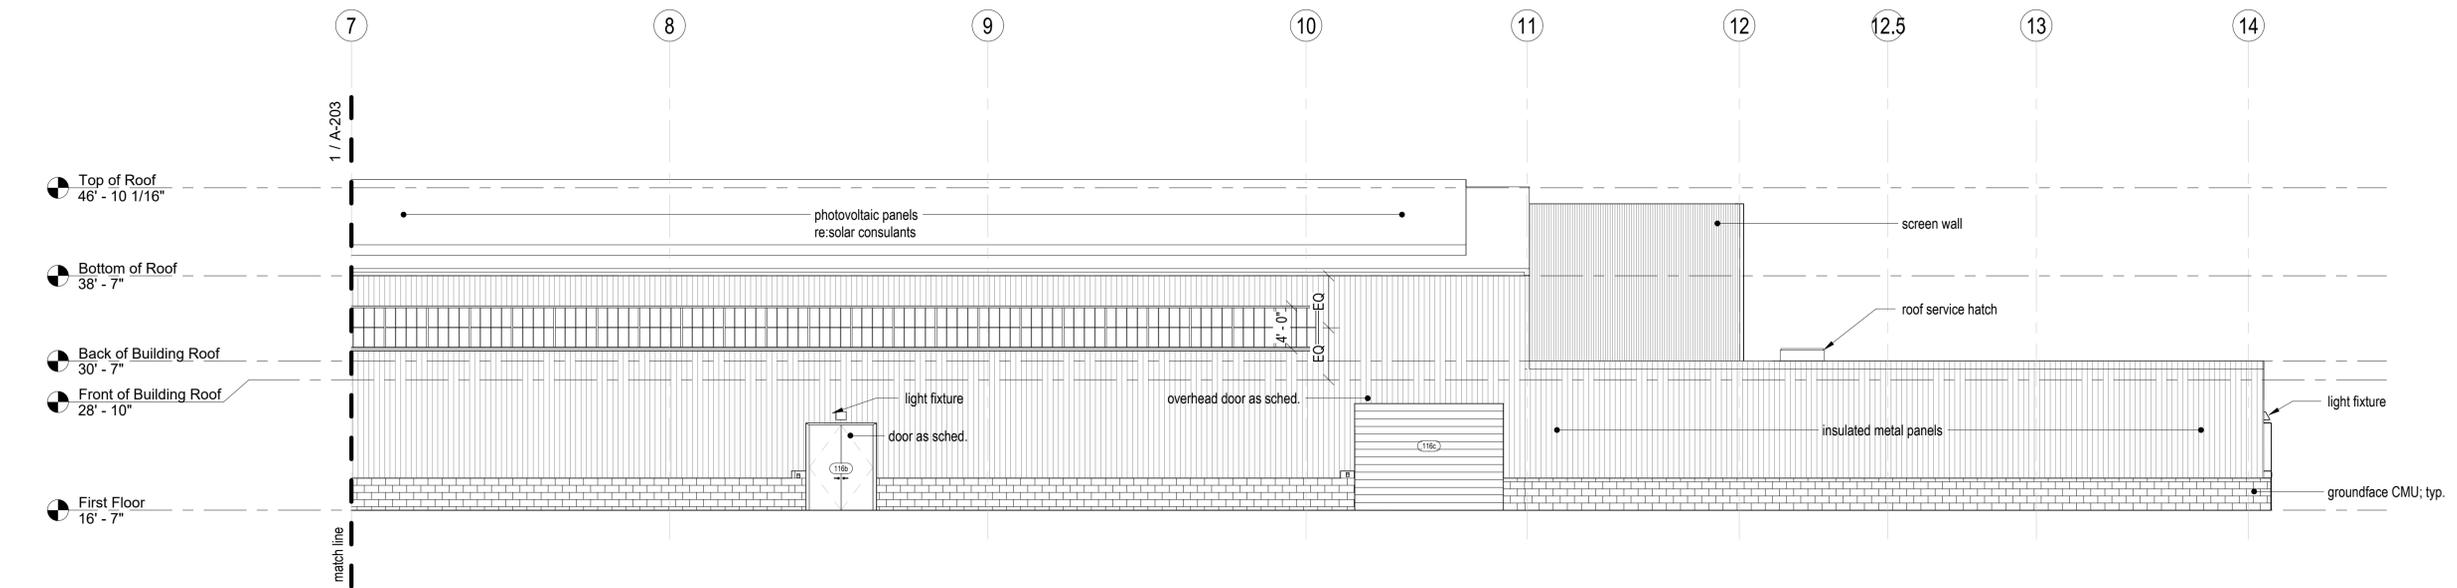


2 East Building Elevation - Right Side
1/8" = 1'-0"

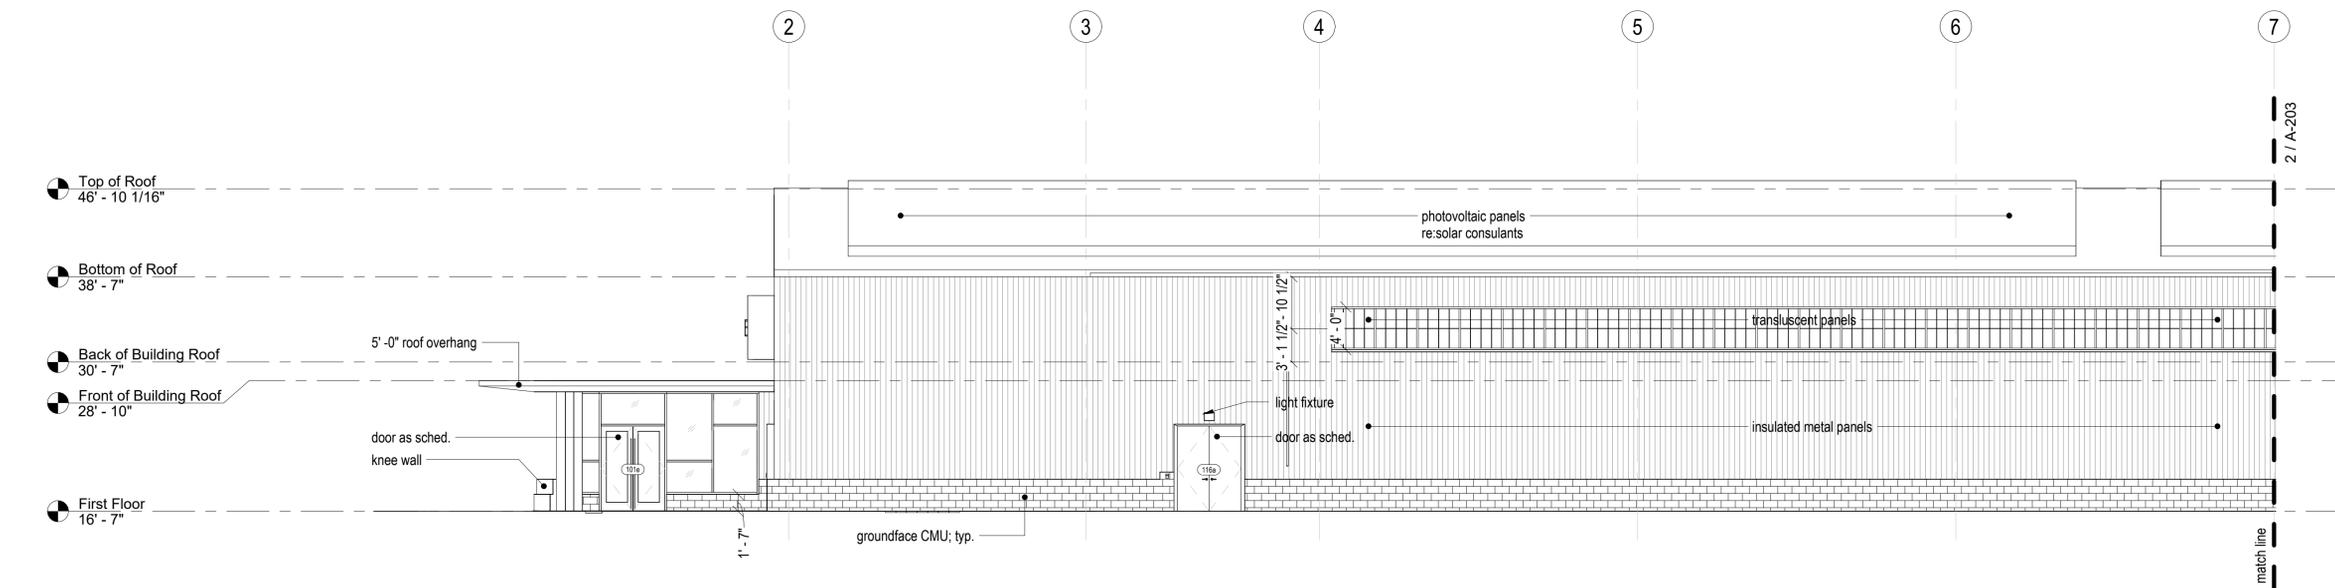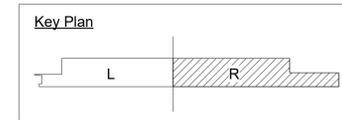


1 East Building Elevation - Left Side
1/8" = 1'-0"

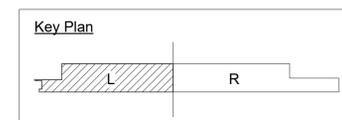

The Galante Architecture Studio, Inc. expressly reserves the common law copyrights in these drawings. These drawings are not to be reproduced in any manner, nor are they to be assigned to a third party without the expressed written permission and consent of The Galante Architecture Studio, Inc.

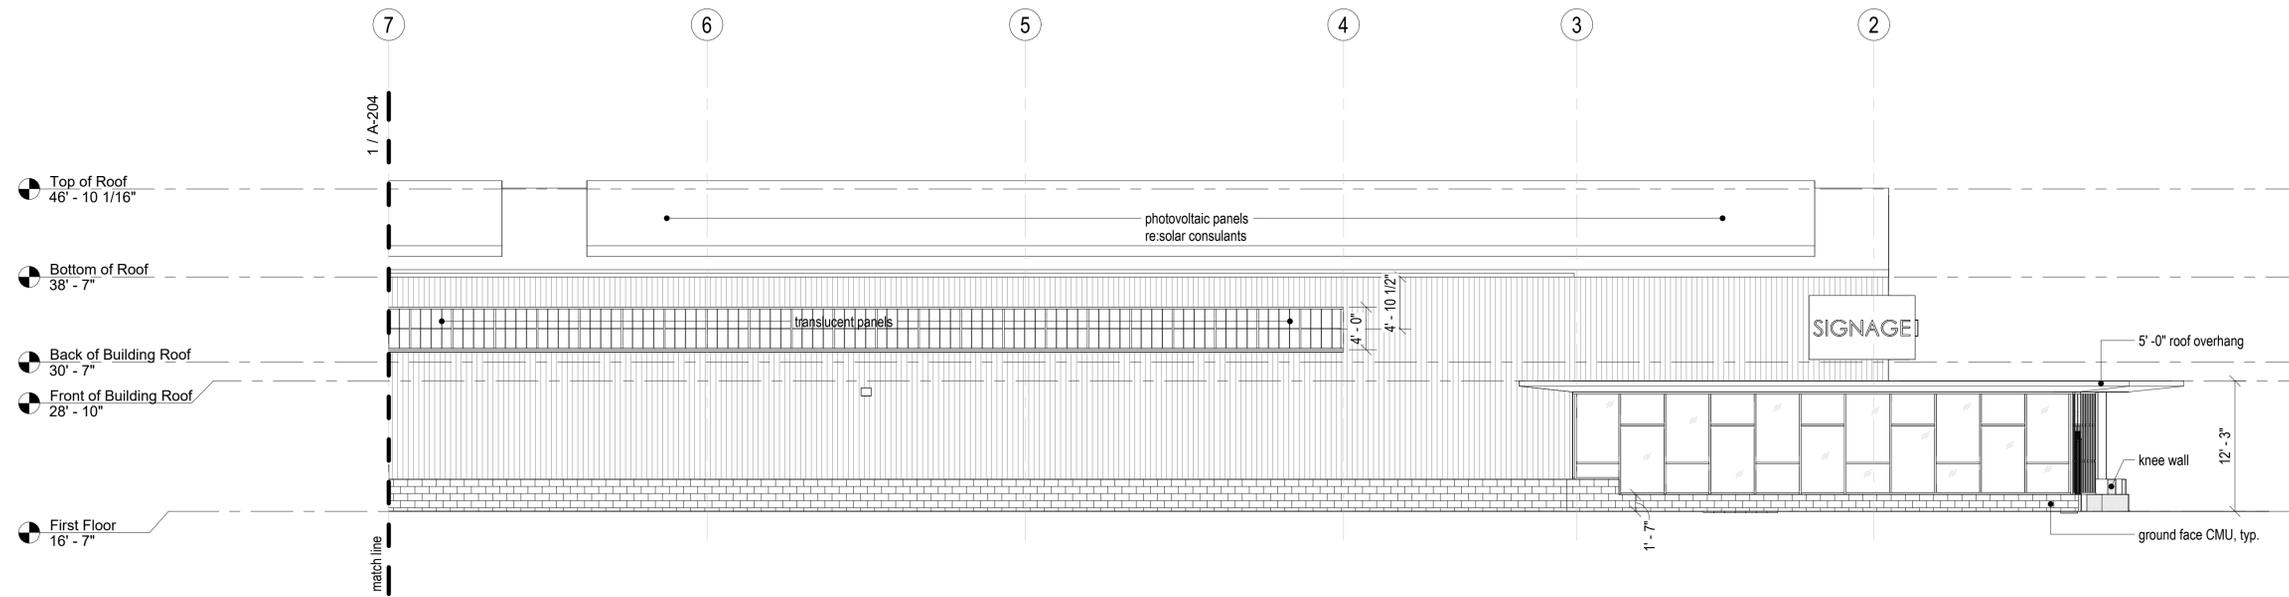

 2 West Building Elevation - Right Side
1/8" = 1'-0"



Project Number
2202
Project Title
Belmont Skating &
Sports Facility

297 Concord Ave,
Belmont, MA 02478

Drawing Title
West Building
Elevations

50% Construction
Documents

Date/Issued For
12.11.2023


**NOT FOR
CONSTRUCTION**

Scale
1/8" = 1'-0"

Drawn By
CT

Drawing Number

A-204

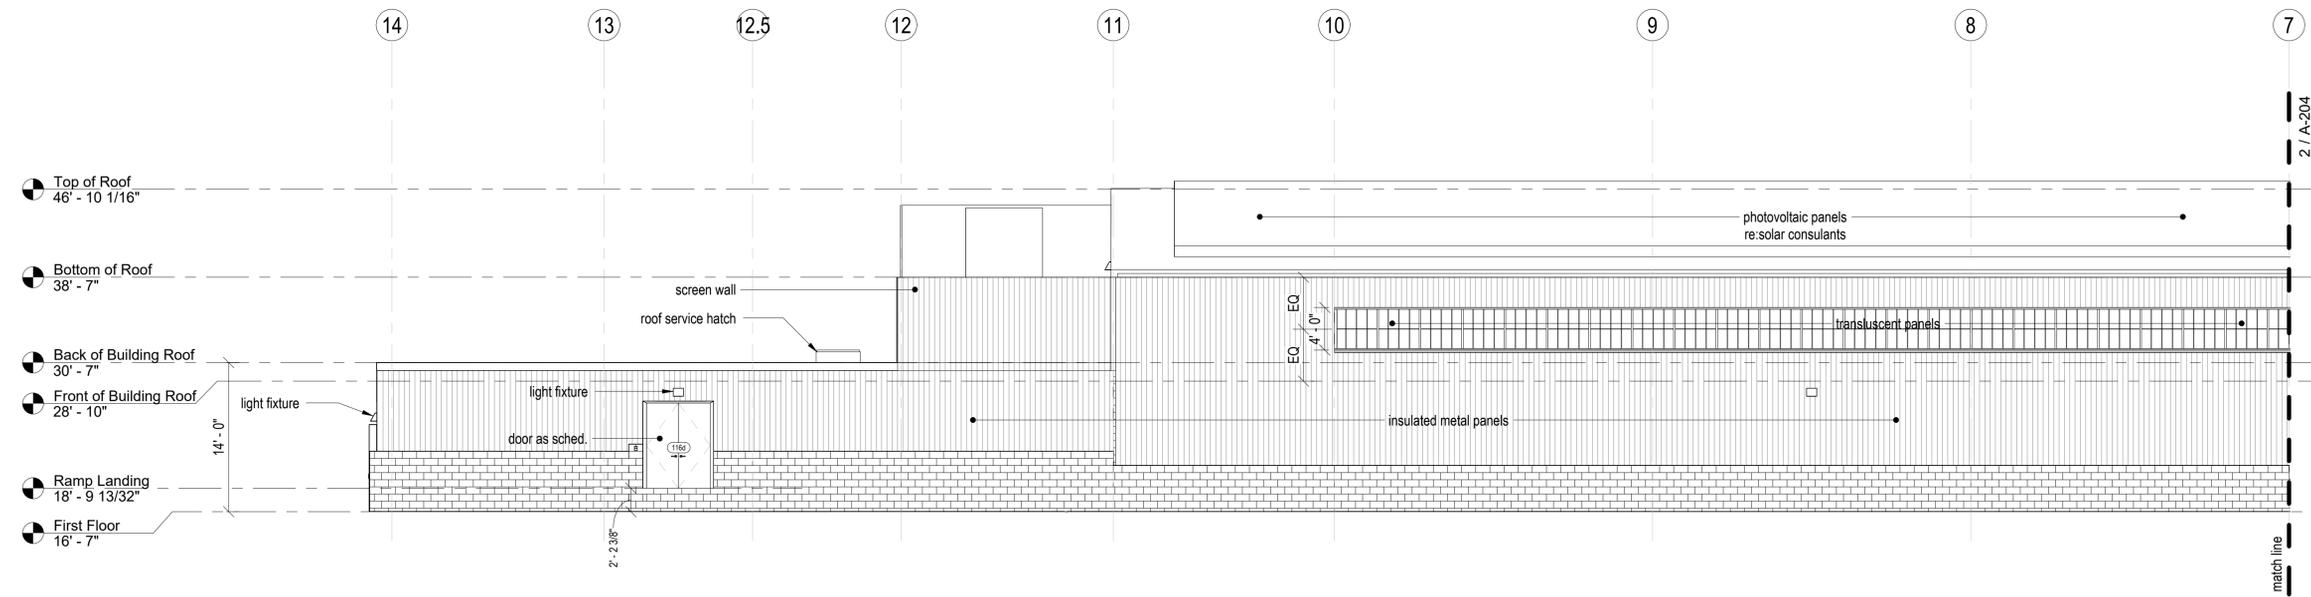

1 West Building Elevation - Left Side
1/8" = 1'-0"

